


LEGEND
 --- = MANUFACTURER SUPPLIED CASCADE PIPEWORK CONFIGURATION

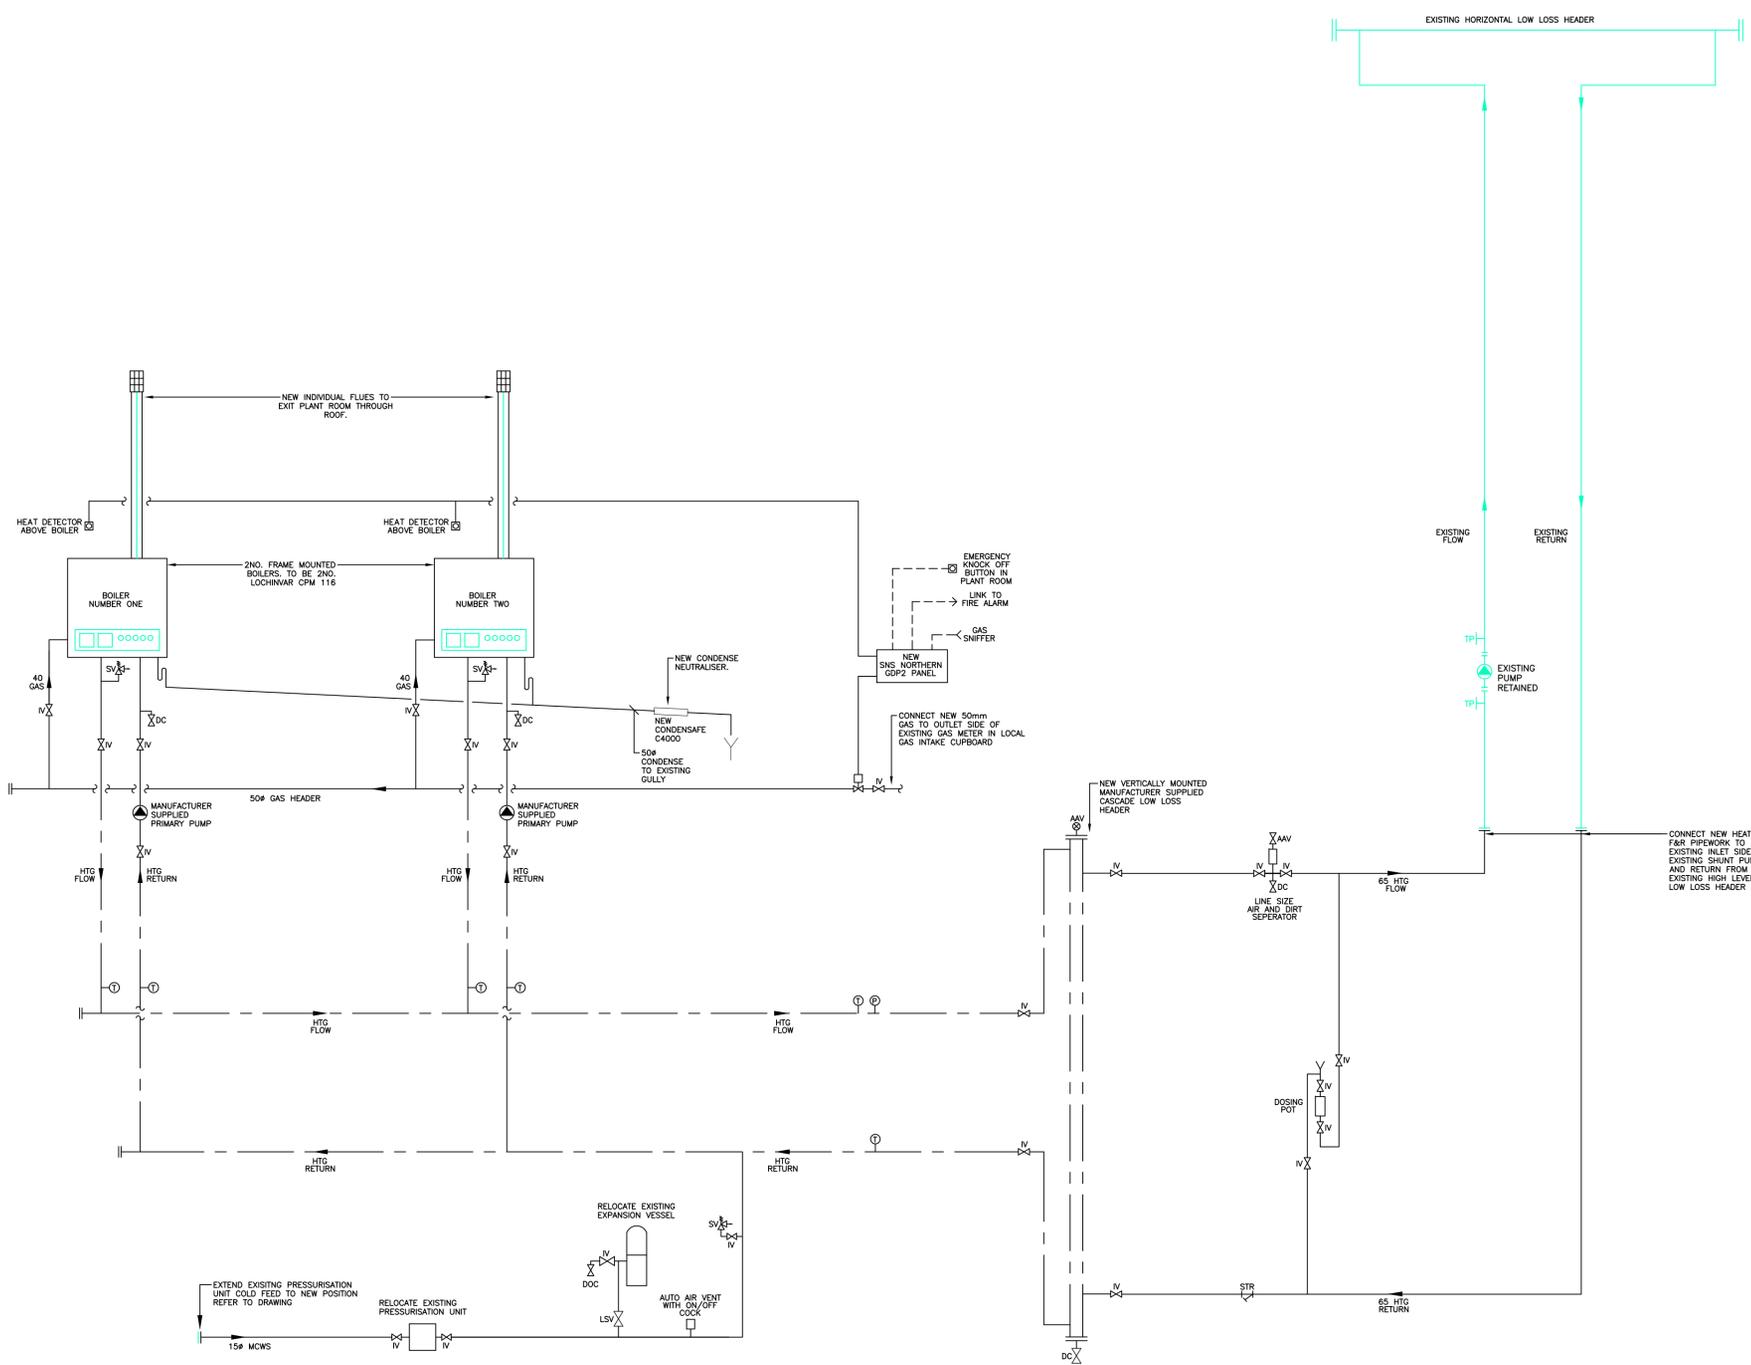

Rev.	Date	Designed	Drawn	Checked
T	31.01.19	EH	KG	EH

P PRELIMINARY ISSUE

Status / Amendments

- NOTE:
1. This drawing shall be read in conjunction with all other contract documentation.
 2. Do not scale from this drawing.
 3. The contractor is to verify all dimensions, tolerances and references on site prior to commencement of the works.
 4. The routes of the pipework is generally as indicated on the drawing, however, the contractor is to allow for all offsets, bends etc. as required to give complete and operational installation.
 5. Contractor shall check proposed mechanical plant fits within site constraints prior to ordering.
 6. Existing Heating system to be drained down locally to allow new heating connections to be made.
 7. Allow to commission and balance the flow rate through the revised heating system on completion of the installation. The contractor shall confirm flow rates prior to works taking place on completion of the works these flow rates shall be matched.
 8. The contractor shall allow to clean all strainers prior to the system.
 9. The contractor shall allow for the boilers to be commissioned by the manufacturer.
 10. Final locations of all thermostats and sensors are to be agreed on site prior to commencement of the works.



Project Title
 MEDBOURNE PAVILION
 BOILER REPLACEMENT

Drawing Title
 MECHANICAL SERVICES
 SCHEMATIC

Date 31.01.2018	Drawing No. M002
Drawn KG	Project No. 1351
Checked EH	Revision T
Approved EH	Paper Size / Scale NTS@A1

Heaton Design & Engineering Ltd
 14 Church Green, Wilney,
 Oxfordshire, OX28 4AW
 Tel: +44(0) 1993 357337
 www.heatonde.co.uk