


This Drawing is protected by Copyright. It may not be reproduced in any form or by any means for any purpose without the written consent of Kernow Services Design Ltd. Do not scale. All Dimensions to be checked on site and verified prior to commencing Works / Manufacture. Any discrepancies to be reported to Kernow Services Design Ltd. These Drawings reflect the layouts for the purposes of design only. The Contractor shall be responsible for producing their own Working and Co-ordination drawings prior to commencing their installations. If these drawings are used for Construction purposes it is done so at the Contractor's Risk.

Scale Bar: 1:50
0 1 2 3 4 5 6

- GENERAL NOTES**
- A. THIS DRAWING IS NOT TO BE SCALED FROM.
 - B. ALL DIMENSIONS SHOWN ARE IN MILLIMETERS UNLESS OTHERWISE STATED.
 - C. THIS DRAWING SHALL BE READ IN CONJUNCTION WITH THE PROJECT MECHANICAL PLANT SCHEDULES.
 - D. THIS DRAWING MUST BE READ IN CONJUNCTION WITH ALL CONSULTANTS, SUB-CONSULTANTS AND ARCHITECTS PROJECT DRAWINGS.

- NOTES**
1. NEW LUMINAIRE TO BE ADDED TO THE EXISTING LIGHTING CIRCUIT. CIRCUIT TO BE TESTED AND INSPECTED PRIOR TO CONNECTION. ANY ISSUES TO BE BROUGHT TO THE ATTENTION OF THE ENGINEER FOR INSTRUCTION BEFORE WORK IS UNDERTAKEN.
 2. FOR LUMINAIRE DETAILS SEE DRAWING NUMBER 1099-KSD-DR-E-10-001

- LIGHTING**
- 1 way light switch
 - 2 way light switch
 - Intermediate light switch
 - No of gangs
 - Dimmer switch
 - PIR for extract fan - Volt free contacts

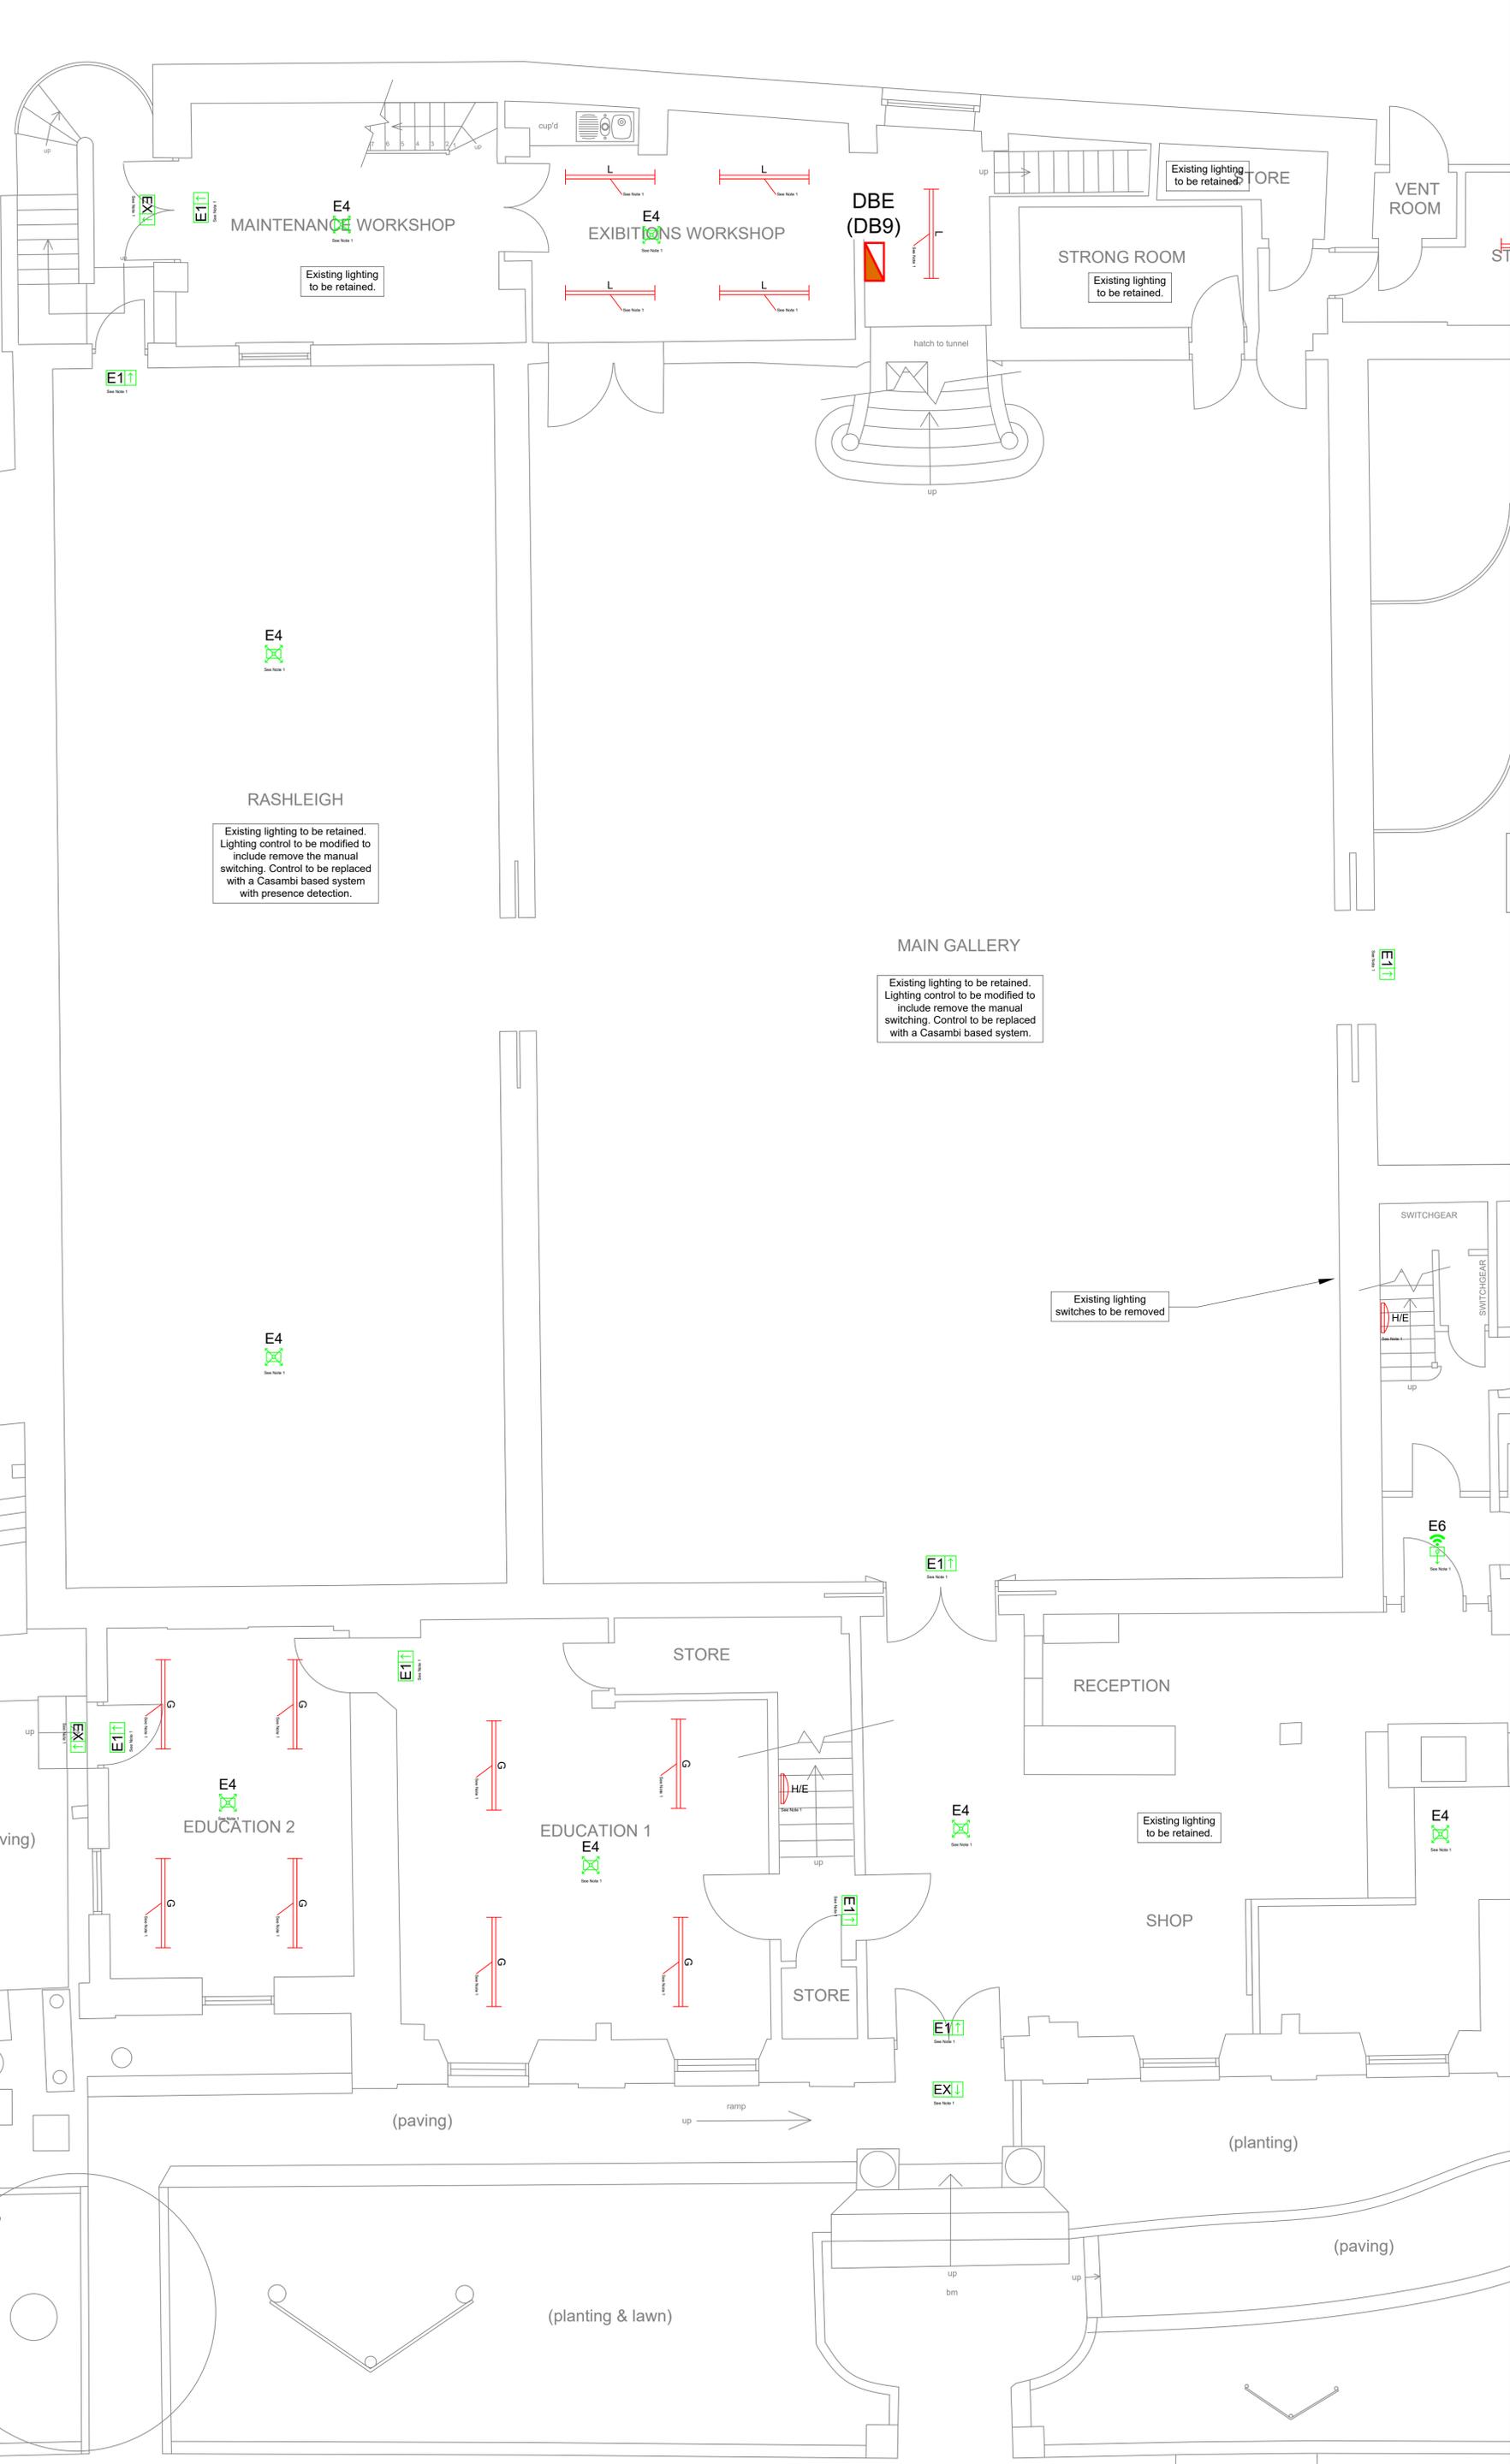

T1	18/09/2023	Tender Issue	MA	CC	MA
Rev	Date	Revision	Dm	Chk	App



Tel: 07464 605663 email: info@kernowservicesdesign.co.uk
website: www.kernowservicesdesign.co.uk

Client: Royal Cornwall Museum

Project Name: ROYAL CORNWALL MUSEUM TRURO CORNWALL

Drawing Title: GROUND FLOOR LEVEL 1 (PART) LIGHTING AND EMERGENCY LIGHTING LAYOUT

Scale at A1: 1:50

Status: Tender Issue

Drawing No: 1107-KSD-DR-E10-003 Revision: T1