


Proposed Ground Floor Layout

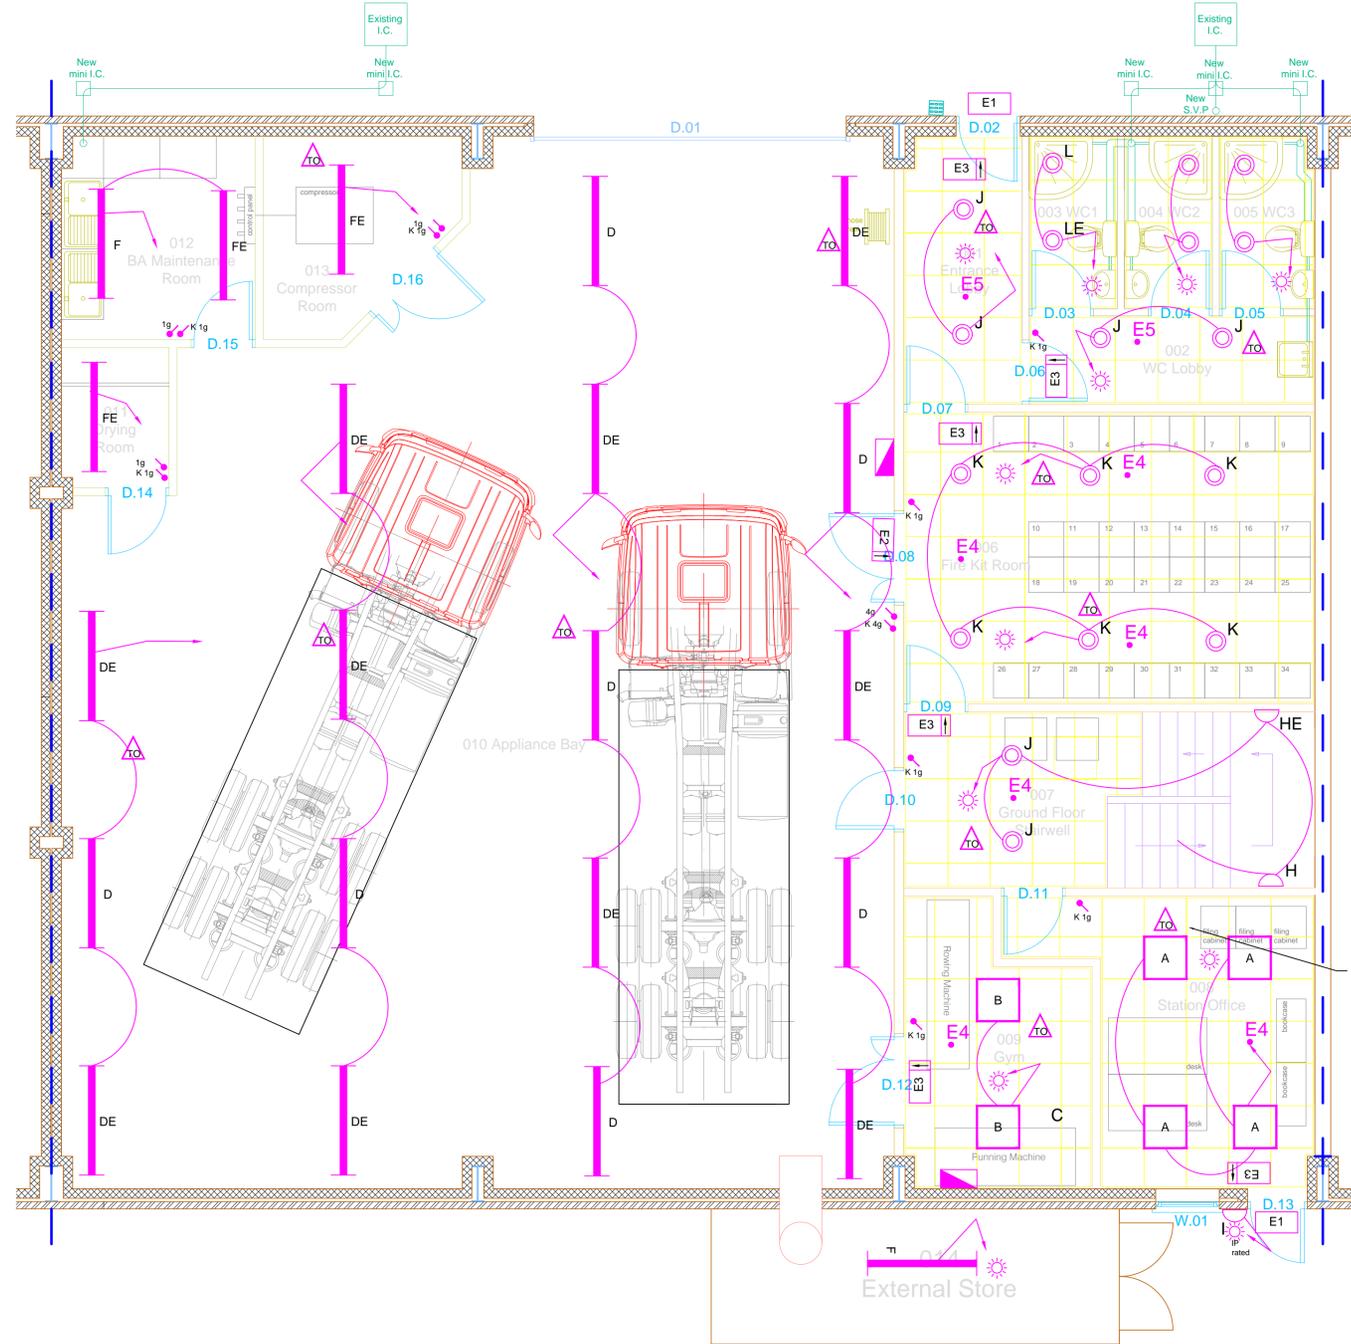

Note:
These drawings are the copyright of
D&d Building Services Consulting
Engineers Ltd. and may only be copied
with prior permission.

All information is indicative only and
must be verified on site by the
contractor.

It is the responsibility of the Contractor
to produce fully co-ordinated and
working detailed drawings

Lighting Legend	
Symbol	Description
	Distribution board location
	Emergency Lighting Keyswitch (n = no. of gangs in multigang switch.)
	1 Gang 2 way light switch (n=number of gangs in a multigang switch)
	1 Gang Intermediate light switch (n=number of gangs in a multigang switch)
	1 Gang 1 way light switch (n=number of gangs in a multigang switch)
	Push to make light switch to operate in conjunction with absence detector (nNo = numbers of switches)
	Push to make light dimmer switch (nNo = numbers of switches)
	Lighting PIR (suffix A indicates absence detector) (suffix HB indicates high Bay detector)
	Microwave Detector (suffix A indicates absence detector)
	600 x 600mm recessed modular LED luminaire with hexaprisim cover, Whitecroft Lighting - Tegen Office LED 36W
	600 x 600mm recessed modular LED luminaire with prismatic cover, Whitecroft Lighting - Tegen Area LED 16W
	600 x 600mm recessed modular LED luminaire with prismatic cover, Whitecroft Lighting - Tegen Area LED 35W
	Suspended LED IP65 luminaire with polycarbonate cover Whitecroft Lighting - ACF DURAL LED 73W
	Suspended LED IP65 luminaire with polycarbonate cover Whitecroft Lighting - ACF DURAL LED 44W
	Suspended LED IP65 luminaire with polycarbonate cover Whitecroft Lighting - ACF DURAL LED 27W
	Surface mounted circular LED luminaire with opal diffuser Whitecroft Lighting - Horizon 360 17W
	Surface mounted circular IP65 LED luminaire with opal diffuser Whitecroft Lighting - Kolo 22W
	Recessed LED downlight Whitecroft Lighting - Esprit LED 24W
	Recessed LED downlight Whitecroft Lighting - Esprit LED 13W
	Recessed 24W LED downlight complete with IP65 clear glass diffuser Whitecroft Lighting - Compact R6 12W
	Surface mounted/Suspended 3 hour duration non-maintained emergency LED sign with arrow as indicated, integral control gear, batteries and LED 3 watt Whitecroft Lighting - Concert EX15
	Recessed 3 hour duration non-maintained emergency LED sign with arrow as indicated, integral control gear, batteries and LED 3 watt Whitecroft Lighting - Concert EX15
	Recessed 3 hour duration non-maintained emergency LED sign with arrow as indicated, integral control gear, batteries and LED 3 watt Whitecroft Lighting - Concert EX1R
	Non-maintained 3hr emergency LED downlight Whitecroft Lighting - Florin E3 Open Area
	Non-maintained 3hr emergency LED downlight Whitecroft Lighting - Florin E3 Corridor

Indicates all lighting in room connected to Turnout Lighting System
Note:
Suffix 'E' indicated luminaire fitted with integral 3 hour duration maintained emergency battery packs and control gear.

TO	Rev	Date	Tender Issue Description	AG	Initials

D&d
Building Services Consulting Engineers Ltd
28 Market Place, Kegworth
Derby, DE74 2EE
Tel: 01509 670100
Fax: 01509 670110

Client
Derbyshire Fire & Rescue Service

Project
Temporary Accomodation

Drawing Title
Proposed Lighting Layout. Ground Floor Level.

Scale: 1:50@ A1 Date: September 2017

Drawn: AG Checked: RJC

Drawing No.: 17.043/ E / 01 Rev / 70

Tender Issue