


DO NOT SCALE

THIS DRAWING IS TO BE USED FOR ELECTRICAL INFORMATION ONLY

LEGEND

- EX EXISTING EMERGENCY BULKHEAD
- A ANSEL MONACH EMERGENCY NON-MAINTAINED FITTING
- B ANSEL DISCO EMERGENCY SWITCHED BULKHEAD
- CE ANSEL PROLINE LINEAR EMERGENCY SWITCHED FITTING

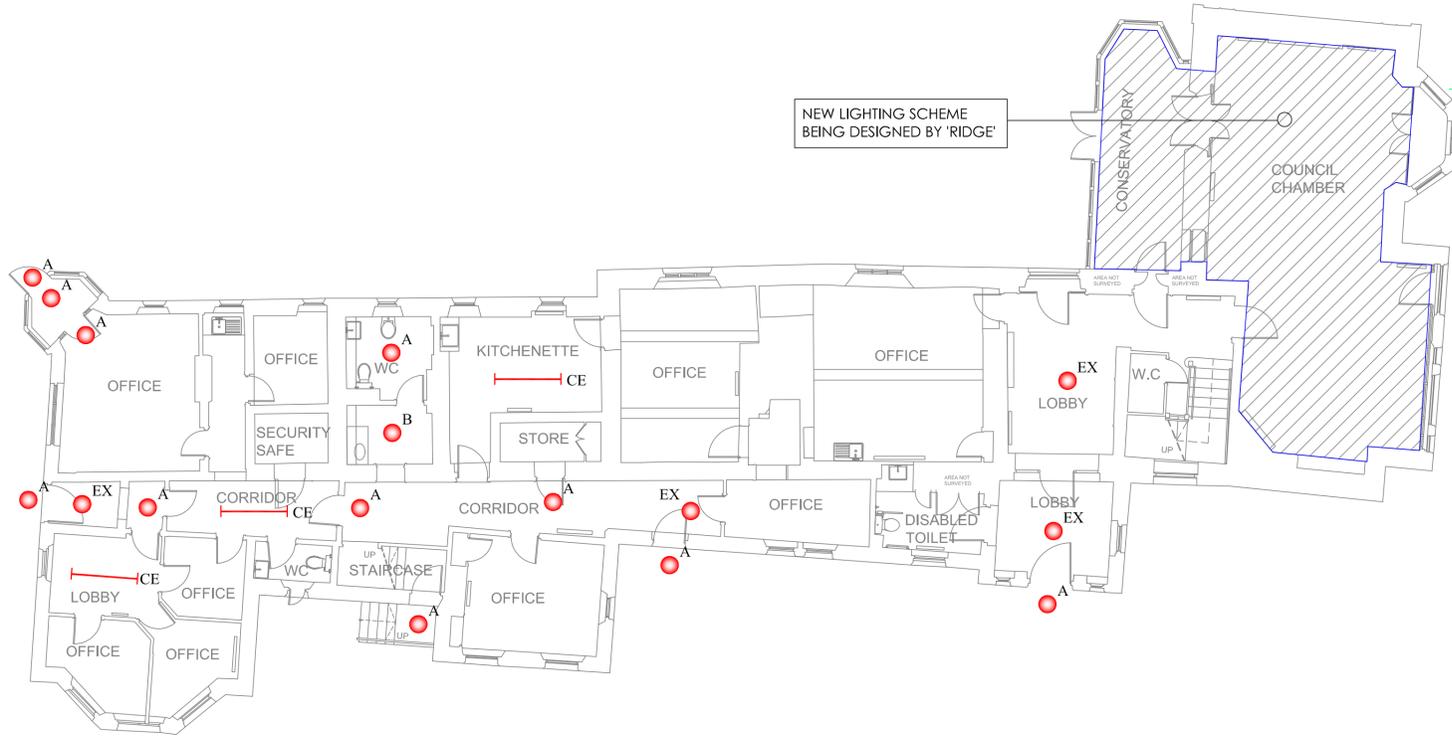

27.07.20 A ISSUED FOR APPROVAL

APPROVAL



Cumnor Road, Wootton, Boars Hill, Oxford OX1 5JW  
 E-Mail: [info@loweoliver.co.uk](mailto:info@loweoliver.co.uk) Tel: 01865 322200  
 Website: [www.loweoliver.co.uk](http://www.loweoliver.co.uk) Fax: 01865 326750

PROJECT  
**THE GARTH-PPM WORKS**  
 THE GARTH, LAUNTON RD  
 BICESTER OX26 6PS

TITLE  
**LIGHTING LAYOUT**

Date	JULY 20	Checked	KG	Scale	1:100
Drawn	LO	Amended	-	Drq size	A1

DRAWING No	Revision
<b>000000/001/E01</b>	<b>A</b>