


ELECTRICAL KEY

-  SINGLE SWITCHED WALL SOCKET
-  DOUBLE SWITCHED WALL SOCKET
-  SINGLE SWITCHED WALL SOCKET 1200MM ABOVE FLOOR LEVEL
-  DOUBLE SWITCHED WALL SOCKET 1200MM ABOVE FLOOR LEVEL
-  1 GANG LIGHT SWITCH
-  2 GANG LIGHT SWITCH
-  1GANG 2 WAY LIGHT SWITCH
-  2 GANG 2 WAY LIGHT SWITCH
-  1GANG 3 WAY LIGHT SWITCH
-  2 GANG 3 WAY LIGHT SWITCH
-  EXTERNAL LIGHT
-  EXTERNAL LIGHT - BULKHEAD TYPE
-  LIGHT POINT - PENDANT HOLDER
-  LIGHT POINT - BATTEN HOLDER
-  FLUORESCENT STRIP LIGHT
-  MECHANICAL EXTRACT FAN
-  TELEPHONE POINT
-  SMOKE DETECTOR
-  CALL POINT
-  H1 HEATER

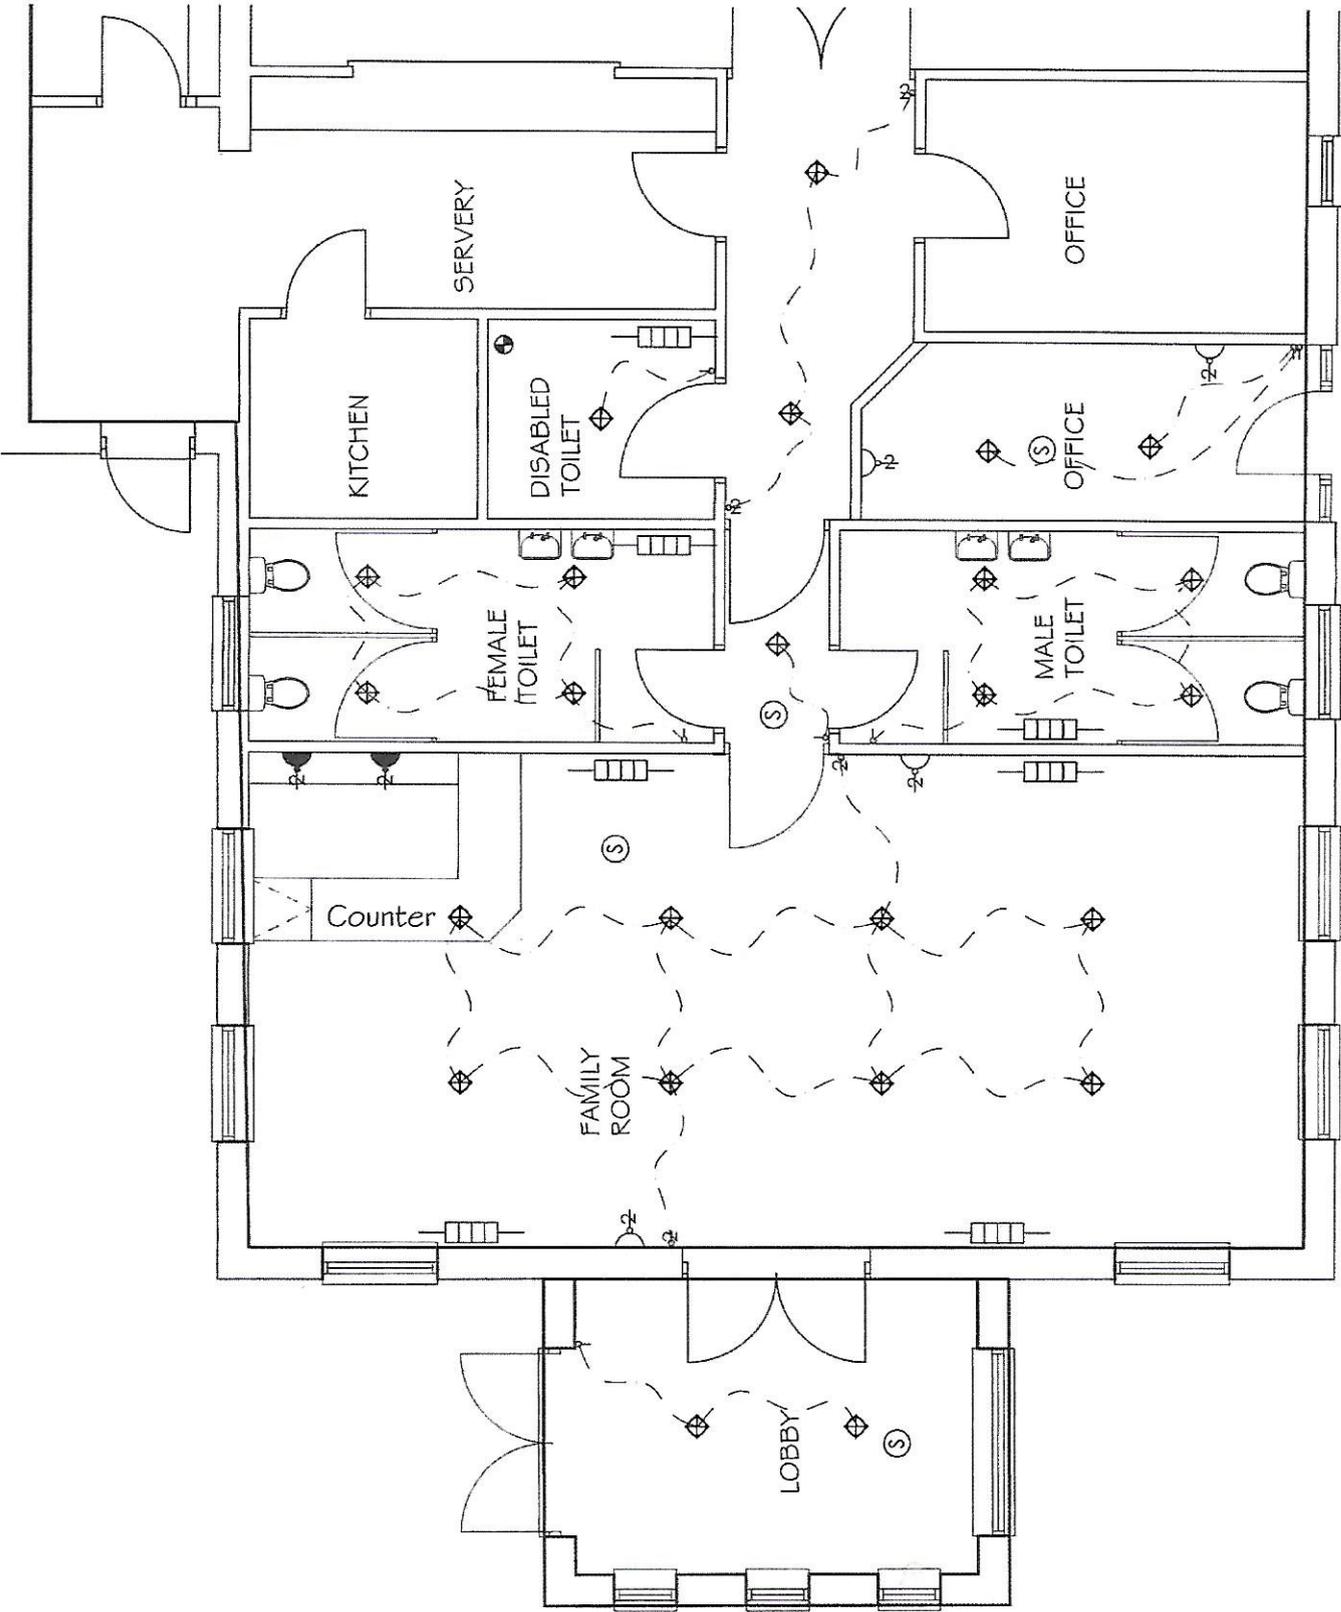

M.T.S Architectural Services
 60 Burykka Avenue
 Clifton
 York
 YO30 6JW
 Tel 01904 626394

Project

PROPOSED NEW SIDE
 ENTRANCE LOBBY, ALTERED
 WINDOWS TO FRONT AND
 REAR ELEVATIONS TOGETHER
 WITH INTERNAL ALTERATIONS
 AT RAWCLIFFE RECREATION
 RAWCLIFFE, YORK

PROPOSED ELECTRICAL
 PLAN

Draw. no. **RR 1/07**

Date: October 2017
 Scale: 1:50