




# PROPOSED LAYOUT

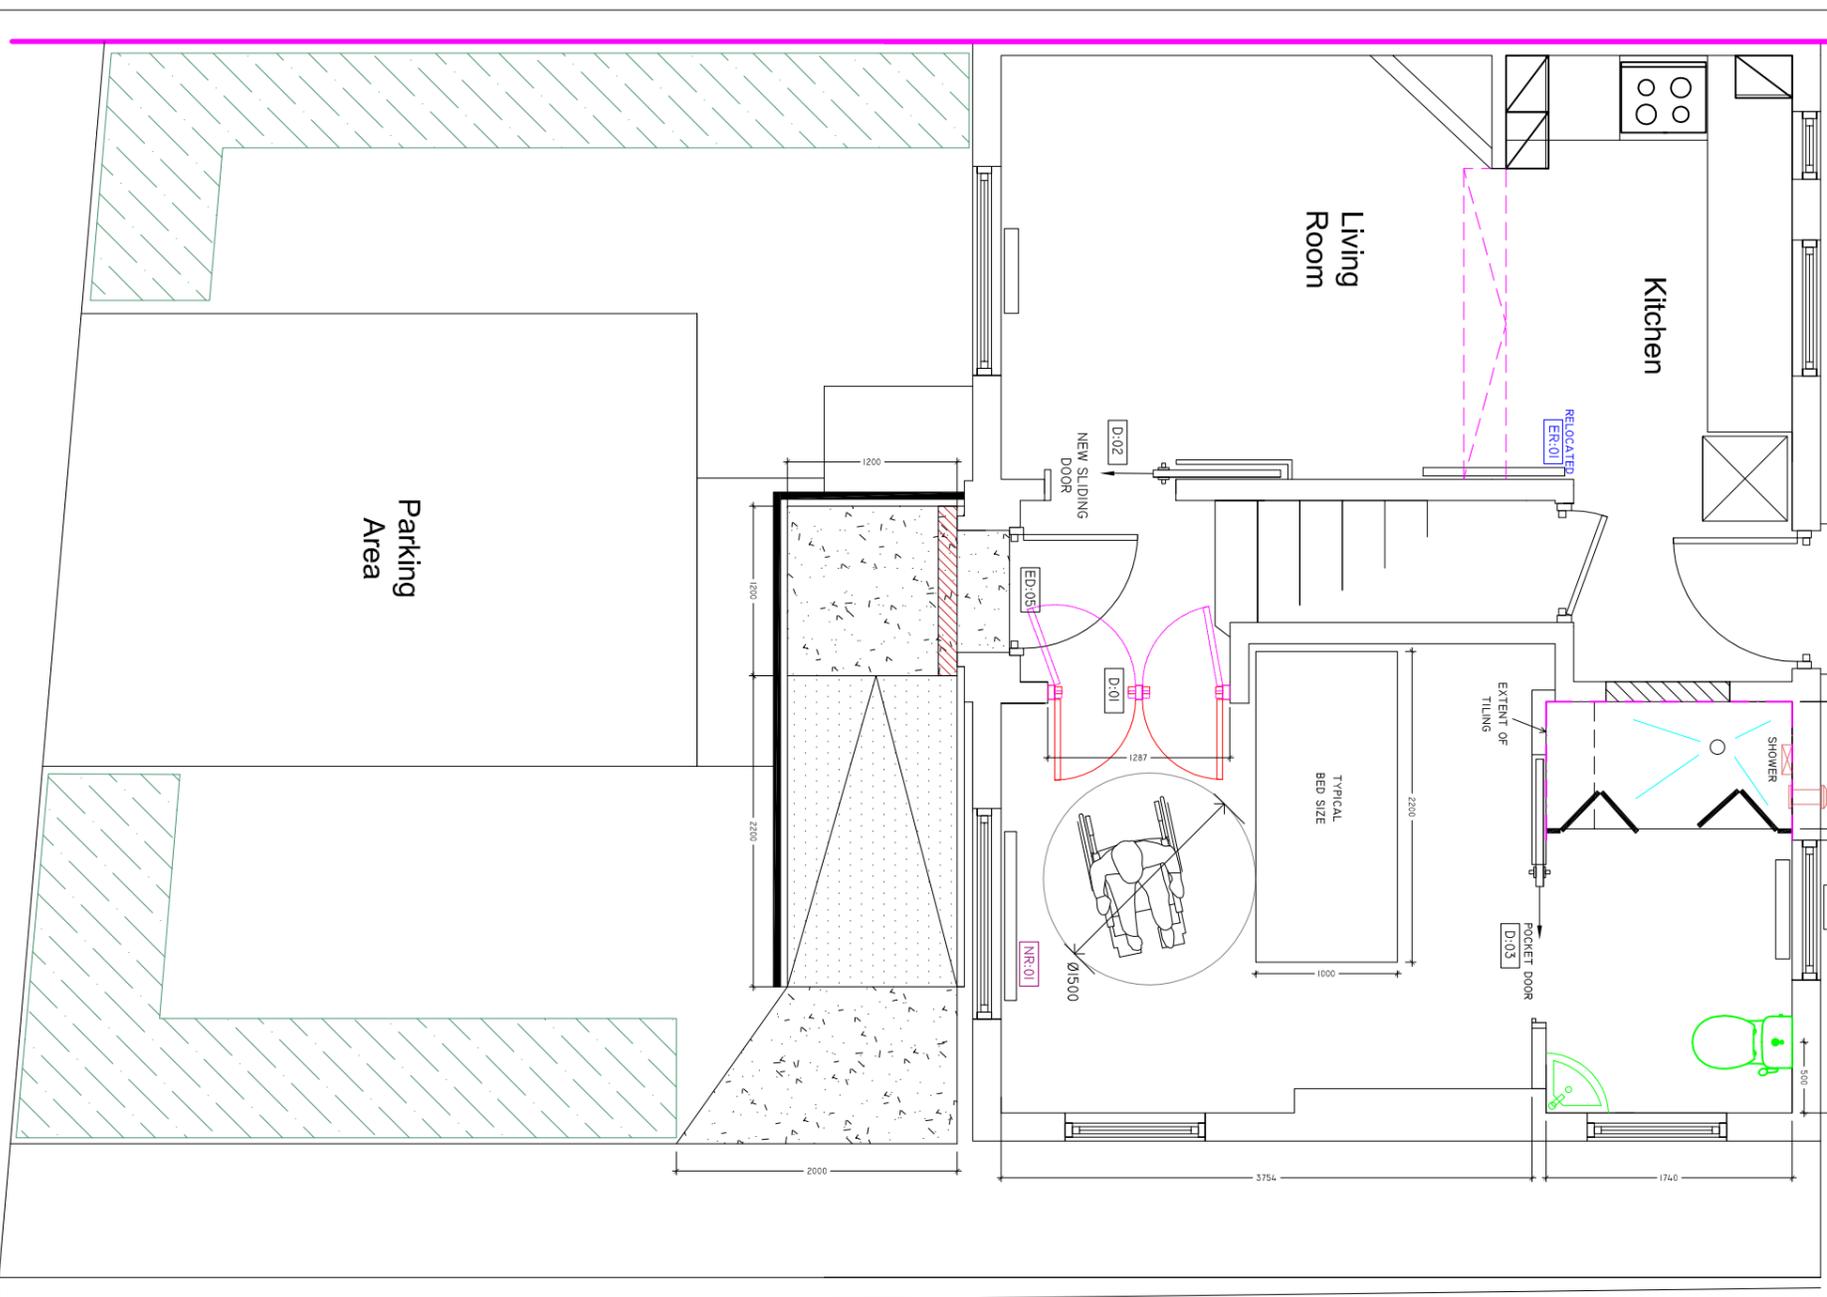

# ELECTRICAL LAYOUT

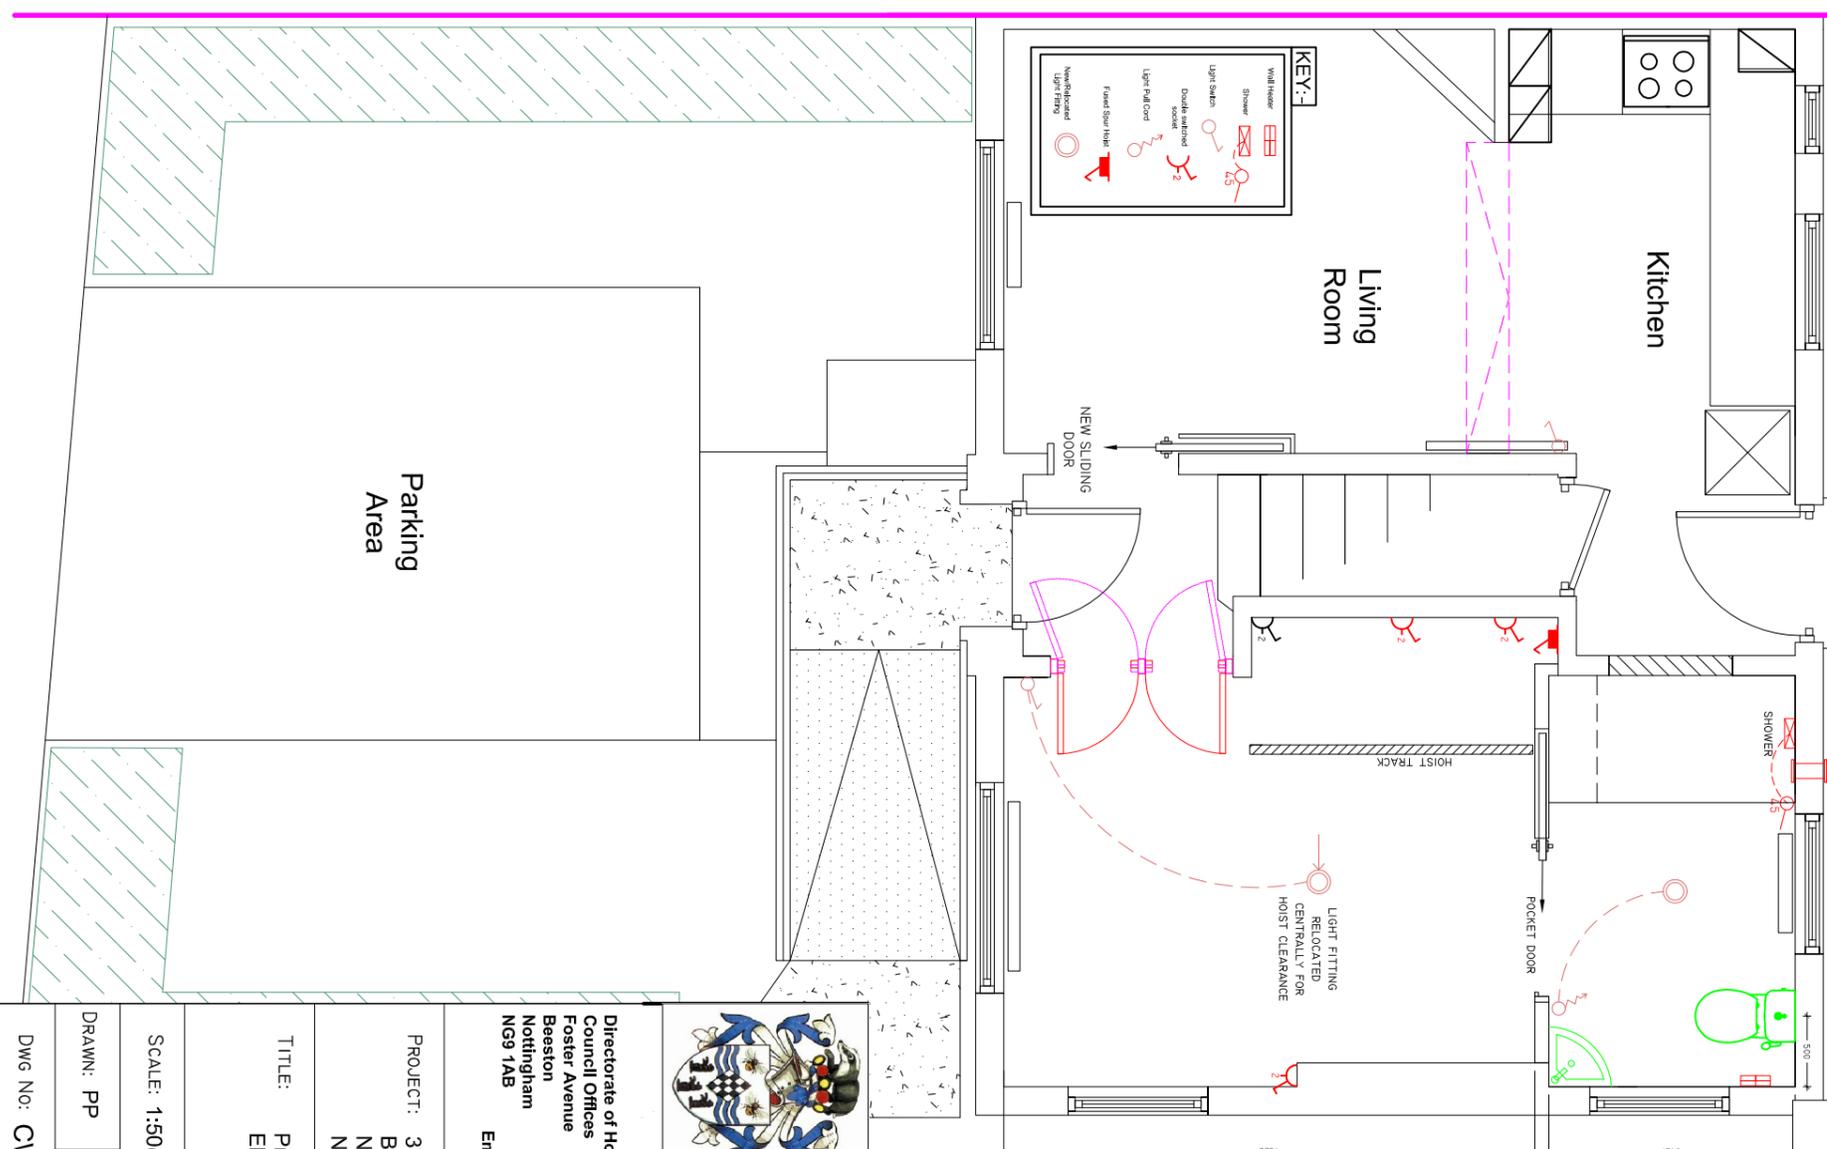

NOTES:  
Do not scale dimensions.  
If in doubt, please ask!

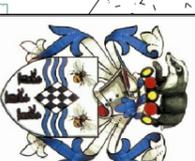

**Broxtove**  
Borough  
COUNCIL

Directorate of Housing, Leisure & Property Services  
Council Offices  
Foster Avenue  
Beeston  
Nottingham  
NG9 1AB  
Tel: (0115) 917 7777  
Fax: (0115) 917 3600  
Email: [env@broxtowe.gov.uk](mailto:env@broxtowe.gov.uk)

PROJECT: 37 Anderson Crescent  
Beeston  
Nottingham  
NG9 2PS

TITLE: Proposed Layout &  
Electrical Layout

SCALE: 1:50@A3 DATE: 25/05/2016

DRAWN: PP CHECK: KJ CDM CHECK:

DWG No: CW16:009:002