


**FINISHES PLAN**

**FINISHES LEGEND:**

- F1 Burmex Ormeauwater 50 Carpet tiles with MDF skirting
  - F2 Burmex Tivoli Carpet tiles with MDF skirting
  - F3 Polyflor Polysafe Ecomax with coved skirting
  - F4 Johnson Tiles Aquila White Bush Hammered with sit on tile skirting
  - W1 Emulsion paint on paint grade fair faced blockwork
  - W2 Emulsion paint on 12.5mm taper edge plasterboard, joints taped and filled, on adhesive dabs
  - W3 Pilkington Prismo 150 x 150mm ceramic glazed tile with feature band
  - C1 Dune Tegular tile in 24mm suspended grid
  - C2 Cerama Guard clipped tile in 24mm moisture resistant grid
  - C3 Emulsion paint on 15mm plasterboard ceiling
- Unless noted otherwise, provide 150mm deep Pilkington Prismo tile splashback to all basins, sinks and worktops
- Where condition W1-C3 occurs provide perimeter trim to ceiling with shadow batten.
- Ceiling type C1 & C2 to have shadow batten detail to perimeter.

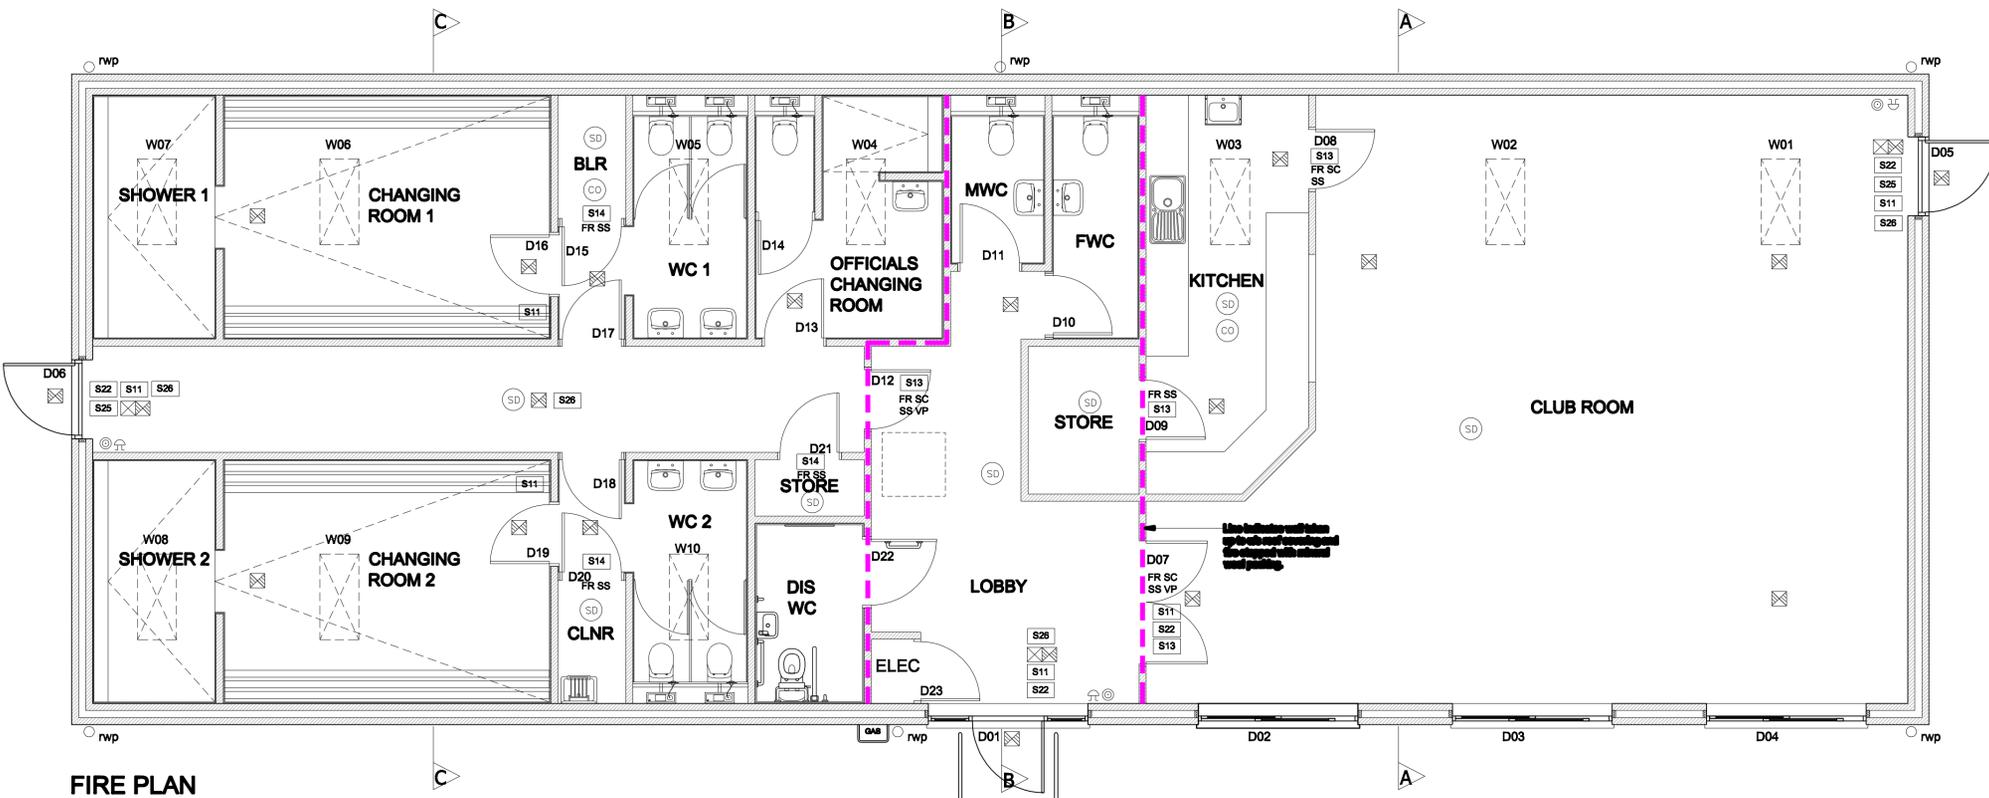

**FIRE PLAN**

**FIRE PLAN LEGEND:**

- FR FIRE RATED DOOR
- SC SELF CLOSER
- SS SMOKE SEALS & INTUMESCENT STRIP
- VP VISION PANEL
- S11 GENERAL FIRE NOTICE
- S13 FIRE DOOR KEEP SHUT (BOTH SIDES OF DOOR) IN 5mm WHITE LETTERING ON BLUE CIRCULAR BACKGROUND LOCATED AT EYE LEVEL
- S14 FIRE DOOR KEEP LOCKED
- S22 FIRE EXIT
- S25 PUSH BAR TO OPEN
- S26 'RUNNING MAN' DIRECTIONAL SYMBOL TO BS5499 PT1 AND EEC DIRECTIVE 92/58
- SD FIRE ALARM SYSTEM MANUAL CALL POINT 1400mm ABOVE GROUND LEVEL
- FD FIRE ALARM SYSTEM GENERAL SOUNDER SOUNDER LOCATIONS TO BE DESIGNED BY SPECIALIST TO ENSURE AUDIBILITY TO ALL AREAS
- SD FIRE ALARM SYSTEM SMOKE DETECTOR (max. 10m spacing) AUTOMATIC FIRE DETECTORS TO BE BETWEEN 500mm - 7500mm FROM A WALL OR PARTITION AUTOMATIC FIRE DETECTORS TO BE MIN. 300mm FROM ANY LIGHT FITTING
- HD FIRE ALARM SYSTEM HEAT DETECTOR
- CO CARBON MONOXIDE DETECTOR
- ALL CABLE FOR FIRE ALARM SYSTEM TO BE 1.5mm FIRE TUFF
- EMERGENCY LIGHTING LUMINAIRE
- EXIT SIGN (INTERNALLY ILLUMINATED)
- 9 LITRE WATER TYPE FIRE EXTINGUISHER TO BS5423
- 13/113 A/B AQUEOUS FOAM TYPE FIRE EXTINGUISHER TO BS5423
- 2 kg CARBON DIOXIDE TYPE EXTINGUISHER TO BS5423 ALL PORTABLE TYPE FIRE EXTINGUISHERS TO BE HUNG ON WALL BRACKETS WITH EXTINGUISHER HANDLE 1000mm ABOVE FLOOR LEVEL

REVISION	DESCRIPTION	DATE

PROJECT  
**Steel Park, Corby**

RDC development consultants

DRAWING TITLE  
**Proposed Finishes & Fire Plans**

PRE-CONSTRUCTION INFORMATION

DRAWN BY: RM	CHECKED BY: SD	AUTH BY: AS
SCALE 1:50 @ A1	DATE August 2017	
DRAWING NUMBER <b>RDC1009-230</b>	REVISION A	