

Project name
Peregrini Lindisfarne Repair Works
Reading Room


Date February 2018 Drawn by JC Scale 1:10, 1:50@A1

Job no 1183 Drawing no TP1 Rev


For
Peregrini Lindisfarne

Drawing title
Tender - Proposed
Plans, Elevations, Section AA & Detail 1

Discrepancies, ambiguities and/or omissions between this drawing and information given elsewhere must be reported to the architect before proceeding.
 This drawing is copyright.
 Dimensions must be checked on site.
 Do not scale off dimensions from this drawing.

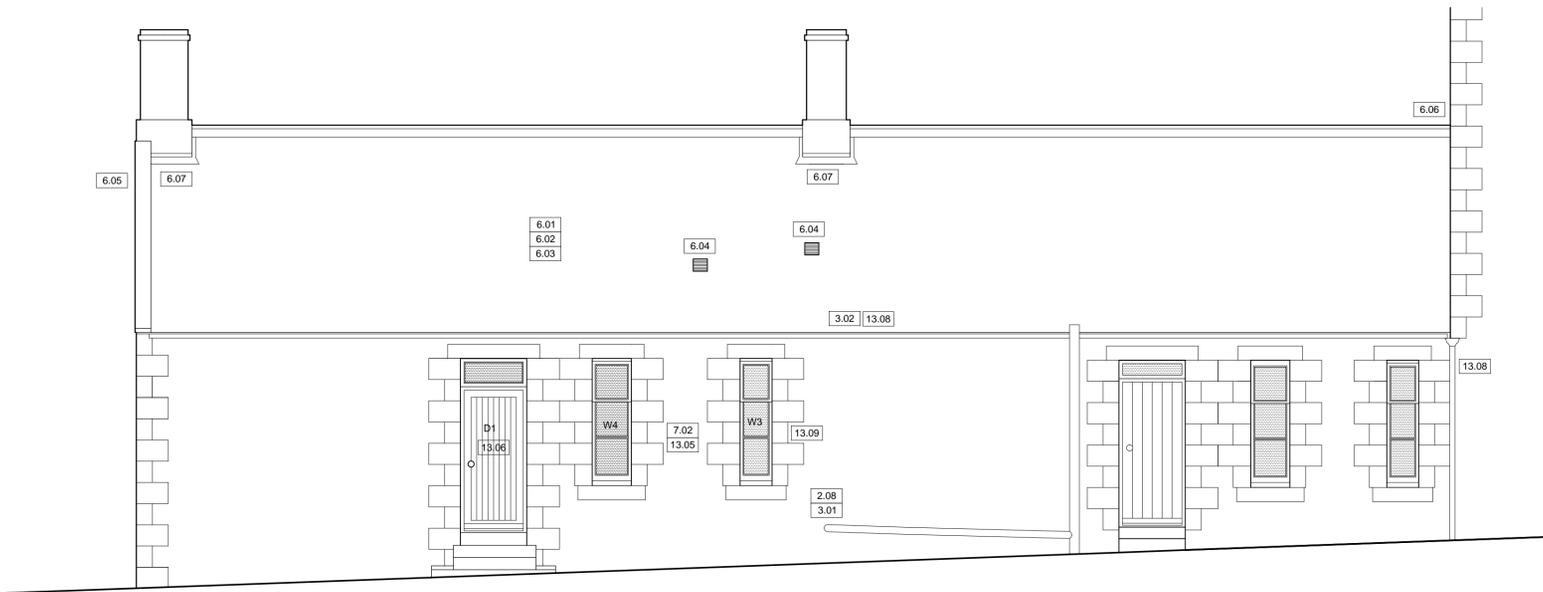


NORTH ELEVATION (1:50)

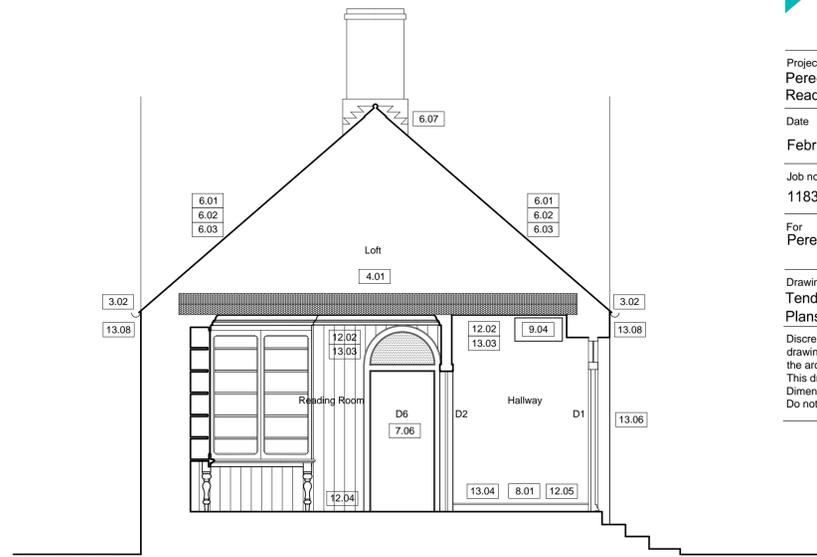


SECTION AA (1:50)

Key (Mechanical and Electrical):
 Those fittings shown in blue on drawing are existing fittings to be retained
 Those fittings shown in red on drawing are new fittings

- Ceiling-mounted pendant light fitting (type TBC)
- Ceiling-mounted LED light fitting (type TBC)
- Wall-mounted external light
- Single light switch
- Double 13A switched socket
- Switched fused spur
- Double 13A switched socket above worktop level
- Switched fused spur above worktop level with single socket connection below worktop
- Electric radiator with frost thermostat
- Electricity distribution board
- Telephone socket
- Ceiling-mounted extractor fan
- Humidistat
- Ceiling-mounted mains wired smoke alarm
- Ceiling-mounted mains wired heat alarm
- Wall-mounted electric water heater

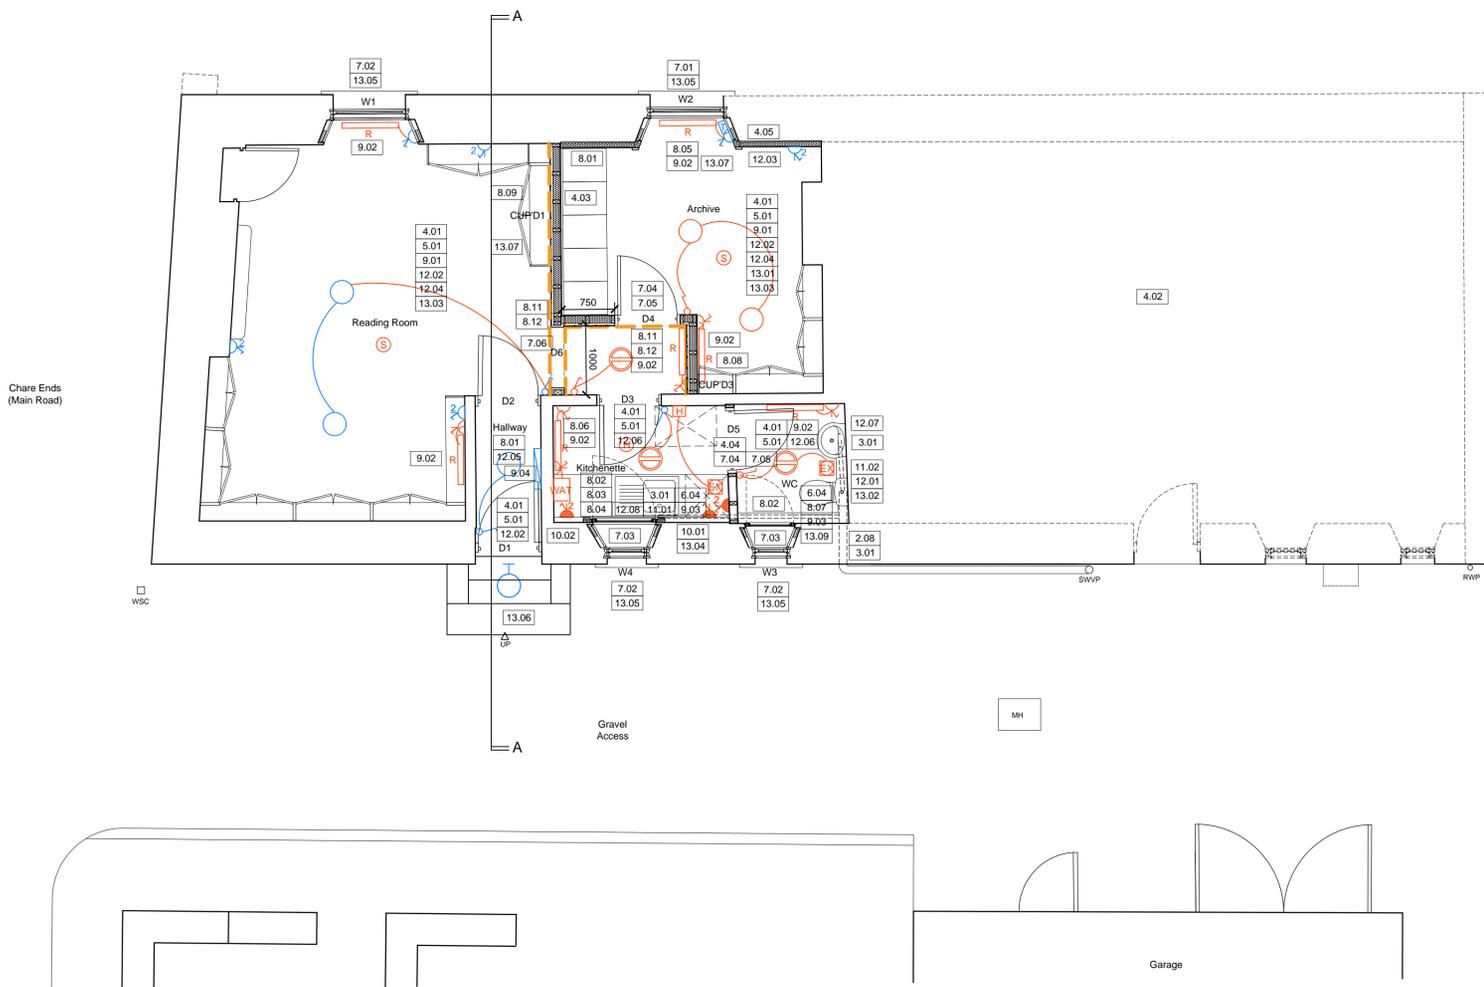

GROUND FLOOR PLAN (1:50)

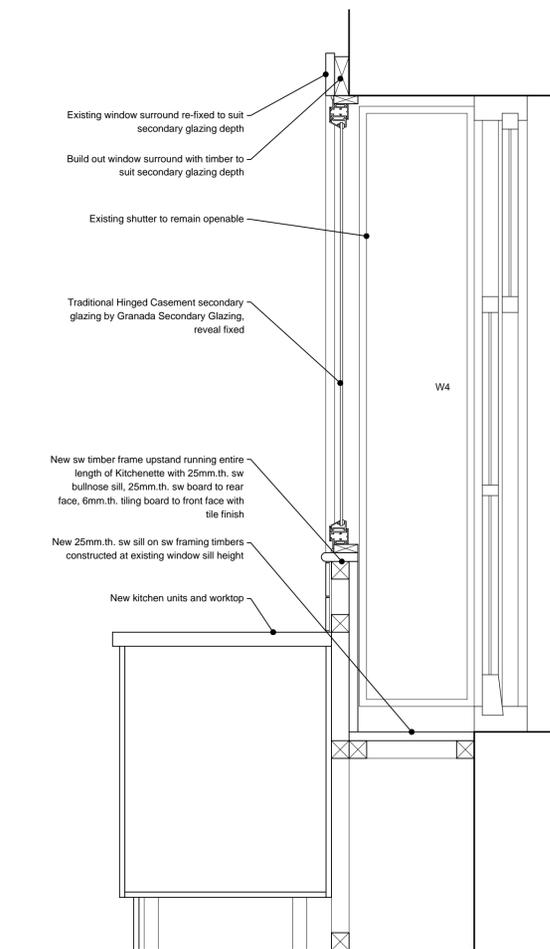

DETAIL 1: KITCHENETTE UPSTAND / SECONDARY GLAZING (1:10)