


Proposed First Floor Layout

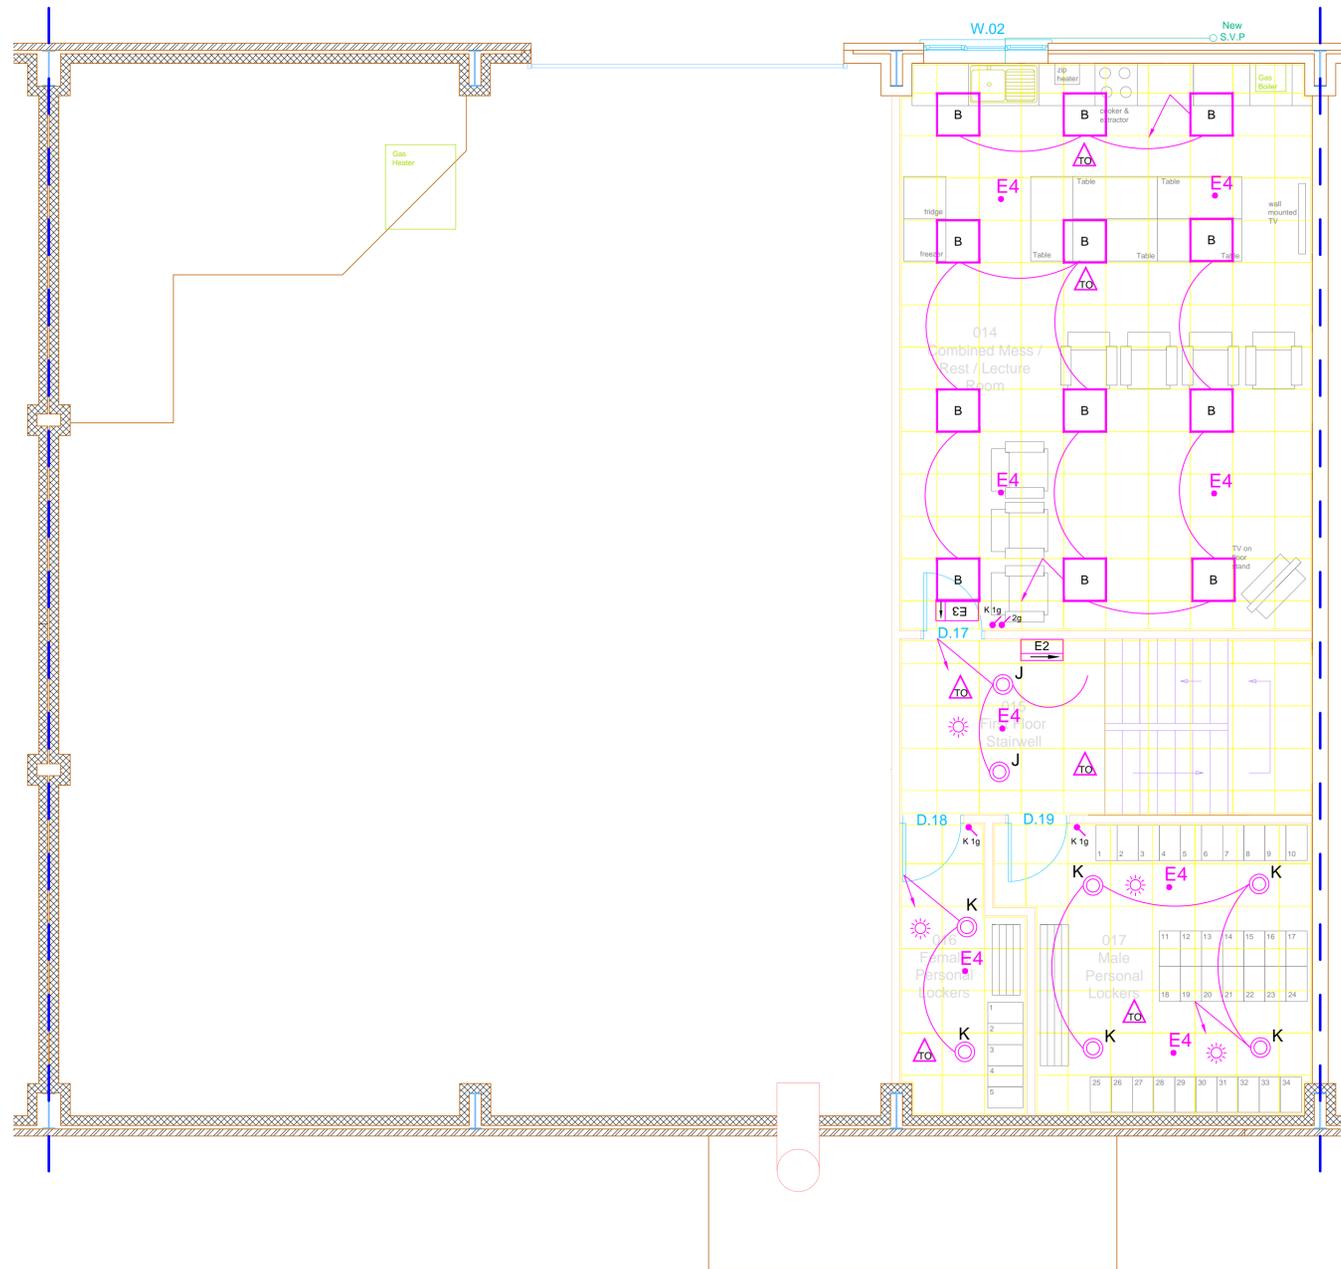

Note:
These drawings are the copyright of
D&d Building Services Consulting
Engineers Ltd. and may only be copied
with prior permission.

All information is indicative only and
must be verified on site by the
contractor.

It is the responsibility of the Contractor to
produce fully co-ordinated and
working detailed drawings

| Lighting Legend | |
|-----------------|--|
| Symbol | Description |
| | Distribution board location |
| | Emergency Lighting Keyswitch (n = no. of gangs in multigang switch) |
| | 1 Gang 2 way light switch (n=number of gangs in a multigang switch) |
| | 1 Gang Intermediate light switch (n=number of gangs in a multigang switch) |
| | 1 Gang 1 way light switch (n=number of gangs in a multigang switch) |
| | Push to make light switch to operate in conjunction with absence detector (nNo = numbers of switches) |
| | Push to make light dimmer switch (nNo = numbers of switches) |
| | Lighting PIR (suffix A indicates absence detector) (suffix HB indicates high Bay detector) |
| | Microwave Detector (suffix A indicates absence detector) |
| | 600 x 600mm recessed modular LED luminaire with hexaprim cover. Whitecroft Lighting - Tegan Office LED 36W |
| | 600 x 600mm recessed modular LED luminaire with prismatic cover. Whitecroft Lighting - Tegan Area LED 16W |
| | 600 x 600mm recessed modular LED luminaire with prismatic cover. Whitecroft Lighting - Tegan Area LED 36W |
| | Suspended LED IP65 luminaire with polycarbonate cover. Whitecroft Lighting - ACF DURAL LED 73W |
| | Suspended LED IP65 luminaire with polycarbonate cover. Whitecroft Lighting - ACF DURAL LED 44W |
| | Suspended LED IP65 luminaire with polycarbonate cover. Whitecroft Lighting - ACF DURAL LED 27W |
| | Surface mounted circular LED luminaire with opal diffuser. Whitecroft Lighting - Horizon 360 17W |
| | Surface mounted circular IP65 LED luminaire with opal diffuser. Whitecroft Lighting - Kolo 22W |
| | Recessed LED downlight. Whitecroft Lighting - Easpirit LED 24W |
| | Recessed LED downlight. Whitecroft Lighting - Easpirit LED 13W |
| | Recessed 24W LED downlight complete with IP65 clear glass diffuser. Whitecroft Lighting - Compact R6 12W |
| | Surface mounted/Suspended 3 hour duration non-maintained emergency LED sign with arrow as indicated, integral control gear, batteries and LED 3 watt. Whitecroft Lighting - Concert EX65 |
| | Surface mounted/Suspended 3 hour duration non-maintained emergency LED sign with arrow as indicated, integral control gear, batteries and LED 3 watt. Whitecroft Lighting - Concert EX15 |
| | Recessed 3 hour duration non-maintained emergency LED sign with arrow as indicated, integral control gear, batteries and LED 3 watt. Whitecroft Lighting - Concert EX1R |
| | Non-maintained 3hr emergency LED downlight. Whitecroft Lighting - Florin E3 Open Area |
| | Non-maintained 3hr emergency LED downlight. Whitecroft Lighting - Florin E3 Corridor |
| | Indicates all lighting in room connected to Turnout Lighting System |

Note:
Suffix 'E' indicated luminaire fitted with integral 3 hour duration maintained emergency battery packs and control gear.

| TO | 03.10.17 | Tender Issue | AG |
|-----|----------|--------------|----------|
| Rev | Date | Description | Initials |
| | | | |

D&d
Building Services Consulting Engineers Ltd
28 Market Place, Kegworth
Derby, DE74 2EE
Tel: 01509 670100
Fax: 01509 670110

Client
**Derbyshire
Fire & Rescue Service**

Project
Temporary Accomodation

Drawing Title
**Proposed Lighting Layout.
First Floor Level.**

Scale: 1:50@ A1 Date: September 2017

Drawn: AG Checked: RJC

Tender Issue Drawing No.: 17.043/ E / 03 Rev /TO