


Existing Floor Plan

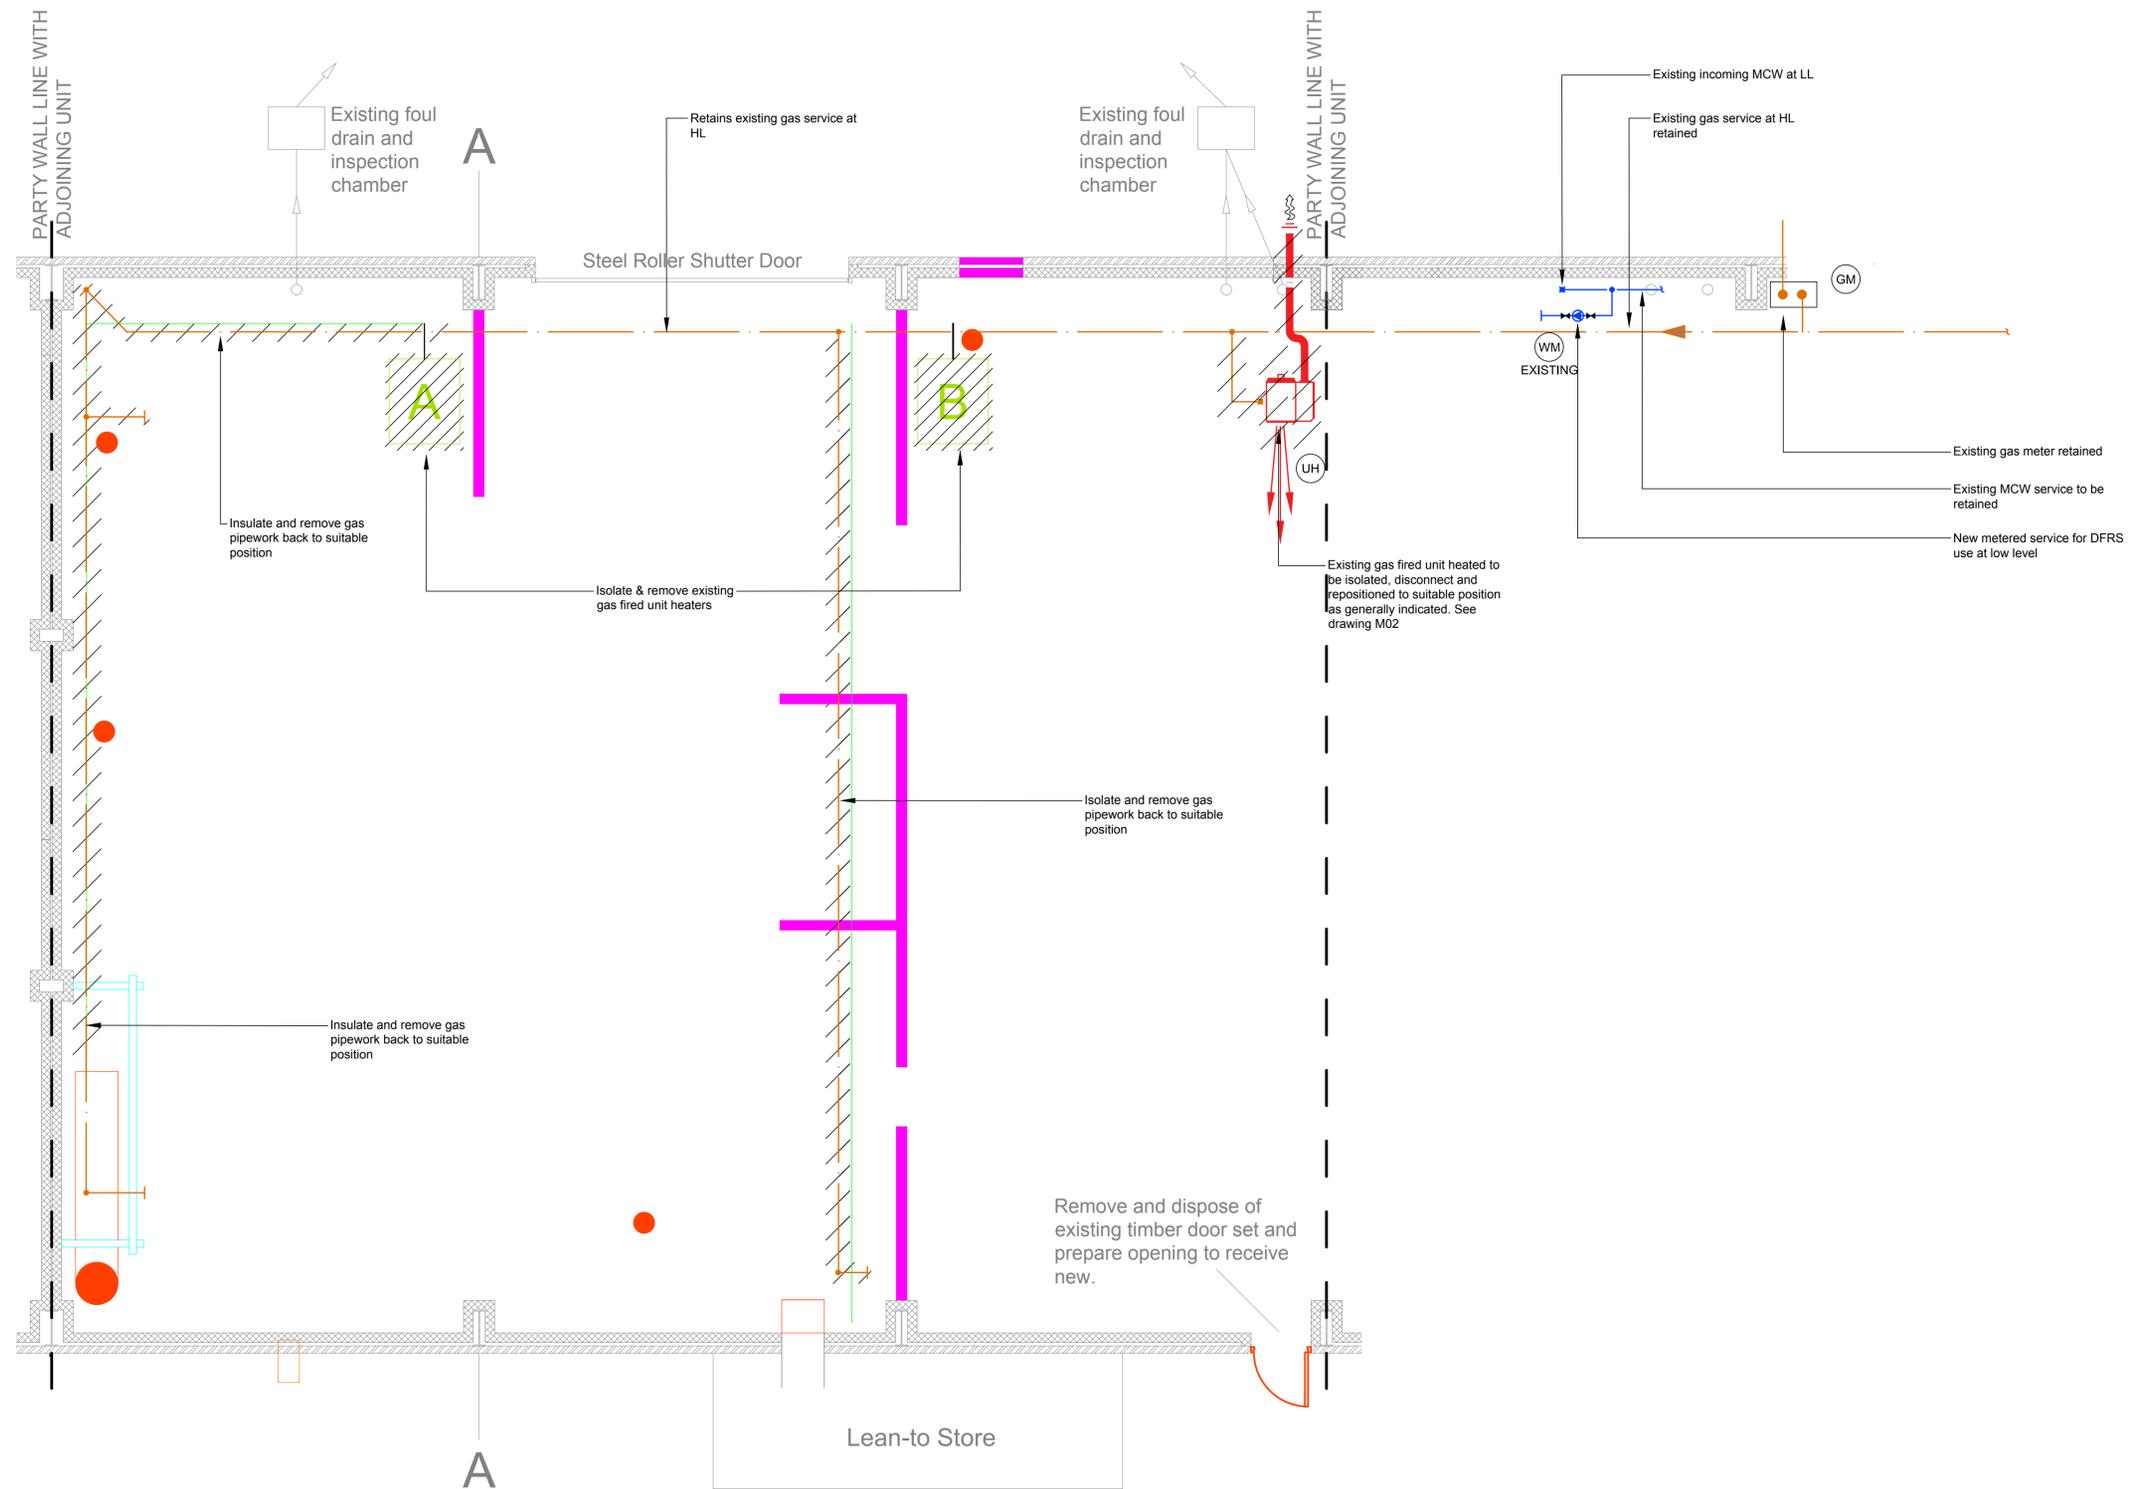

- Note:**
1. These drawings are the copyright of D&d Building Services Consulting Engineers Ltd. and may only be copied with prior permission.
 2. All information is indicative only and must be verified on site by the contractor.
 3. It is the responsibility of the Contractor to produce fully co-ordinated and working detailed drawings.

- Symbol Key:**
- ⊙ GM Gas Meter. As determined by the Contractors Design.
 - ⊙ WM Meter. As determined by the Contractors Design.
 - ⊙ UH Gas Unit Heater. As determined by the Contractors Design.

- Line-type Key:**
- MCW/CWS/BCWS
 - HWS Flow & Return
 - LTHW Variable Temperature Flow & Return
 - LTHW Constant Temperature Flow & Return
 - Fresh Air/Supply Air
 - Extract Air/Exhaust Air
 - Gas Services
 - Refrigeration Services

Rev	Date	Description	Initials

D&d
 Building Services Consulting Engineers Ltd
 28 Market Place, Kegworth
 Derby, DE74 2EE
 Tel: 01509 670100
 Fax: 01509 670110

Client
Derbyshire Fire & Rescue Service

Project
Temporary Accommodation

Drawing Title
Existing Mechanical Services

Scale: 1:50@A1 Date: September 2017

Drawn: FI Checked: PD

Drawing No.: 17.043 / M / 01 Rev / P0

Tender Issue