

Fit Point A




 
Fit Point C

Fit Point A

Fit Point C

Fit Point A

Fit Point C

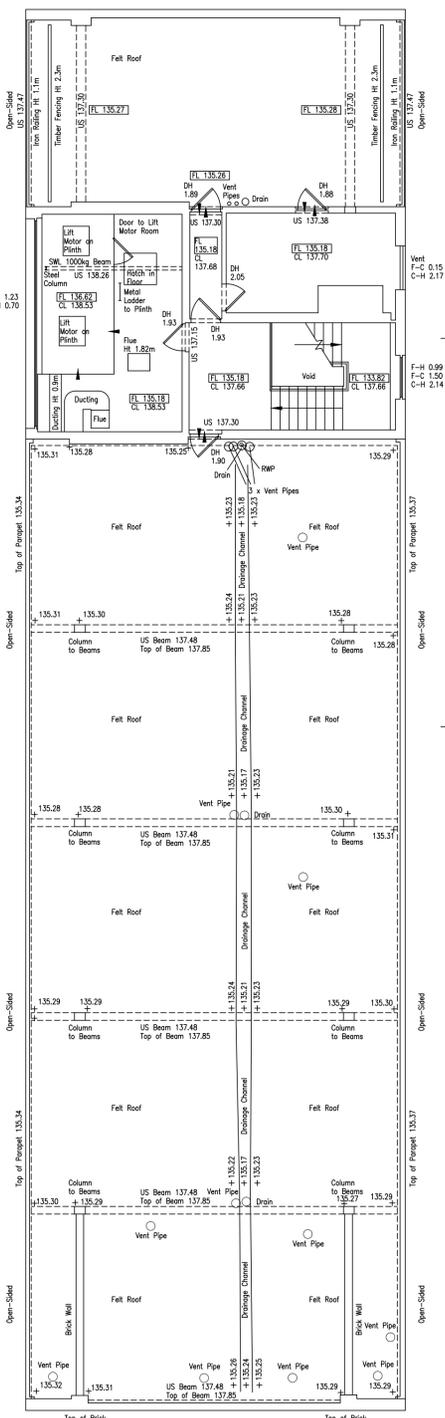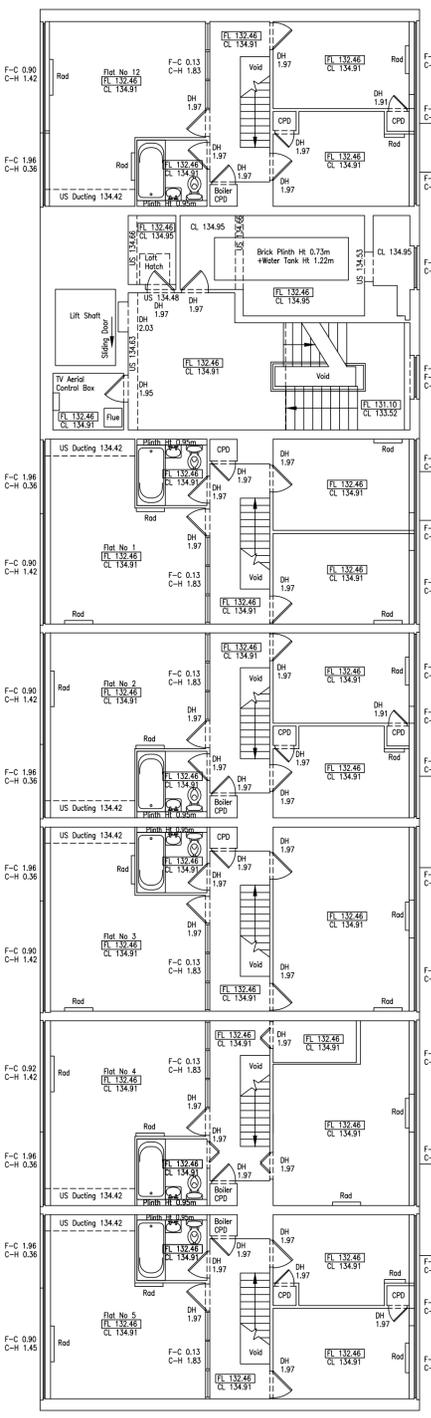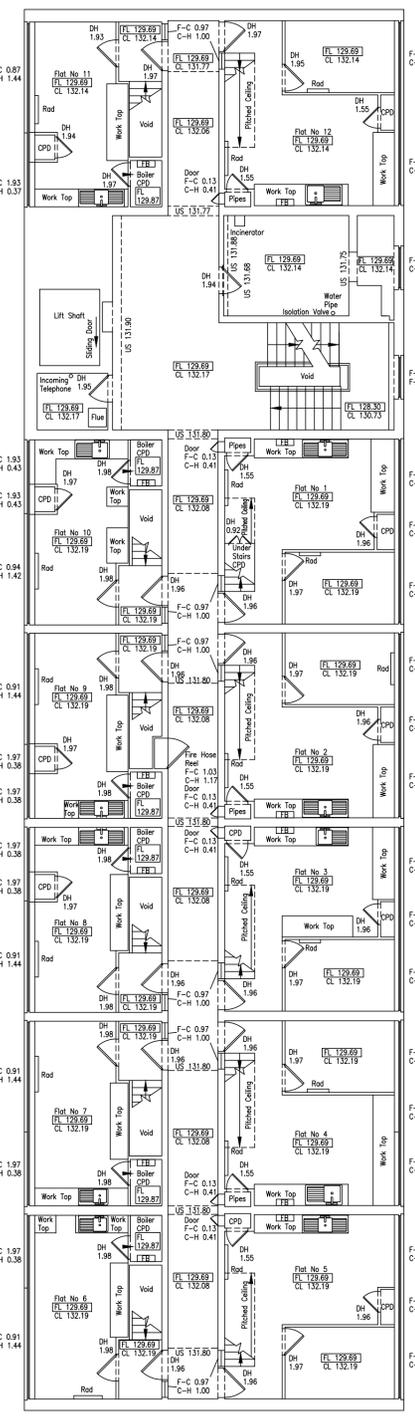

Third Floor Plan

 
Fourth Floor Plan

Roof Plan

Fit Point B


Fit Point B

Fit Point B



Abbreviated Features:		Legend:	
Symbol	Feature	Symbol	Feature
AB	Air Brick	LI	Light
B	Boiler	O/F	Overflow Pipe
C/B	Cover Boarded	P	Pipe
C-H	Chimney Head	P/C	Pipe & Chain
CL	Chain Link	FE	Fire Escape
CL	Ceiling Level	P/R	Post & Rail
CPD	Cupboard	P/W	Post & Wire
CP	Crown Point Level	RD	Roller Door
DR	Drain	RE	Rodding Eye
FE	Fire Exit	RWP	Rainwater Pipe
FL	Floor Level	SD	Sliding Doors
FW	Fuel Water	SSL	Suspended Ceiling Level
GH	Gully	SP	Spring Point Level
I	Insulation Chamber	SW	Soil & Vent Pipe
I/R	Iron Railings	SW	Surface Water
		UL	Under Lint
		VP	Vent Pipe
		VI	Vent
			Radiator
			Emergency Light
			Ship Light
			Wall Mounted Light
			Main Point
			Blank Point
			Light Switch
			Pendant Switch
			Isolator Switch
			Alarm Bell
			Fire Alarm Push
			Smoke Detector
			Alarm Panel
			Thermostat
			Modern
			Face Box
			Electric Box
			Heater
			Water Stop Tap
			Overhead Features

Plan Coordinate Control:-  
N/A  
Level Datum:-  
All Levels relate to OSGB36(02) using GPS

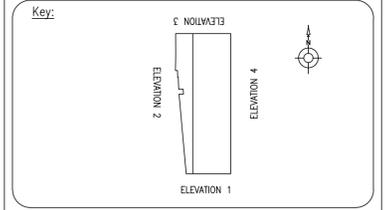

Notes:

REV NO	REV NOTE	DATE	SIGNED
--------	----------	------	--------

6 Franklin's Close, Ecton, Northampton, NN6 0QG  
Tel: 01604 491543 Fax: 01604 790361  
Email: info@globalsurveys.co.uk

Site: Neville House, George Street, Corby  
Client: Corby Borough Council  
Survey Title: Measured Building Survey, Third, Fourth & Roof Floor Plans

Date	June 2017	Scale	1/100 @ A1
Dwg No.	17043-MBS	Surveyor	JAM
Sheet	2 of 4	Checked	SJH