


- Floor Box**
- Existing floor box locations
  - Existing floor box retained
  - Existing floor box relocated
  - New additional floor box to match
  - New 16amp Cmd. mains power
- P1 1No double 3pin socket  
P2 2No double 3pin socket

- Data**
- Wifi access point – 2No RJ45 data sockets
  - D2 2No single RJ45 data sockets
  - D4 4No single RJ45 data sockets

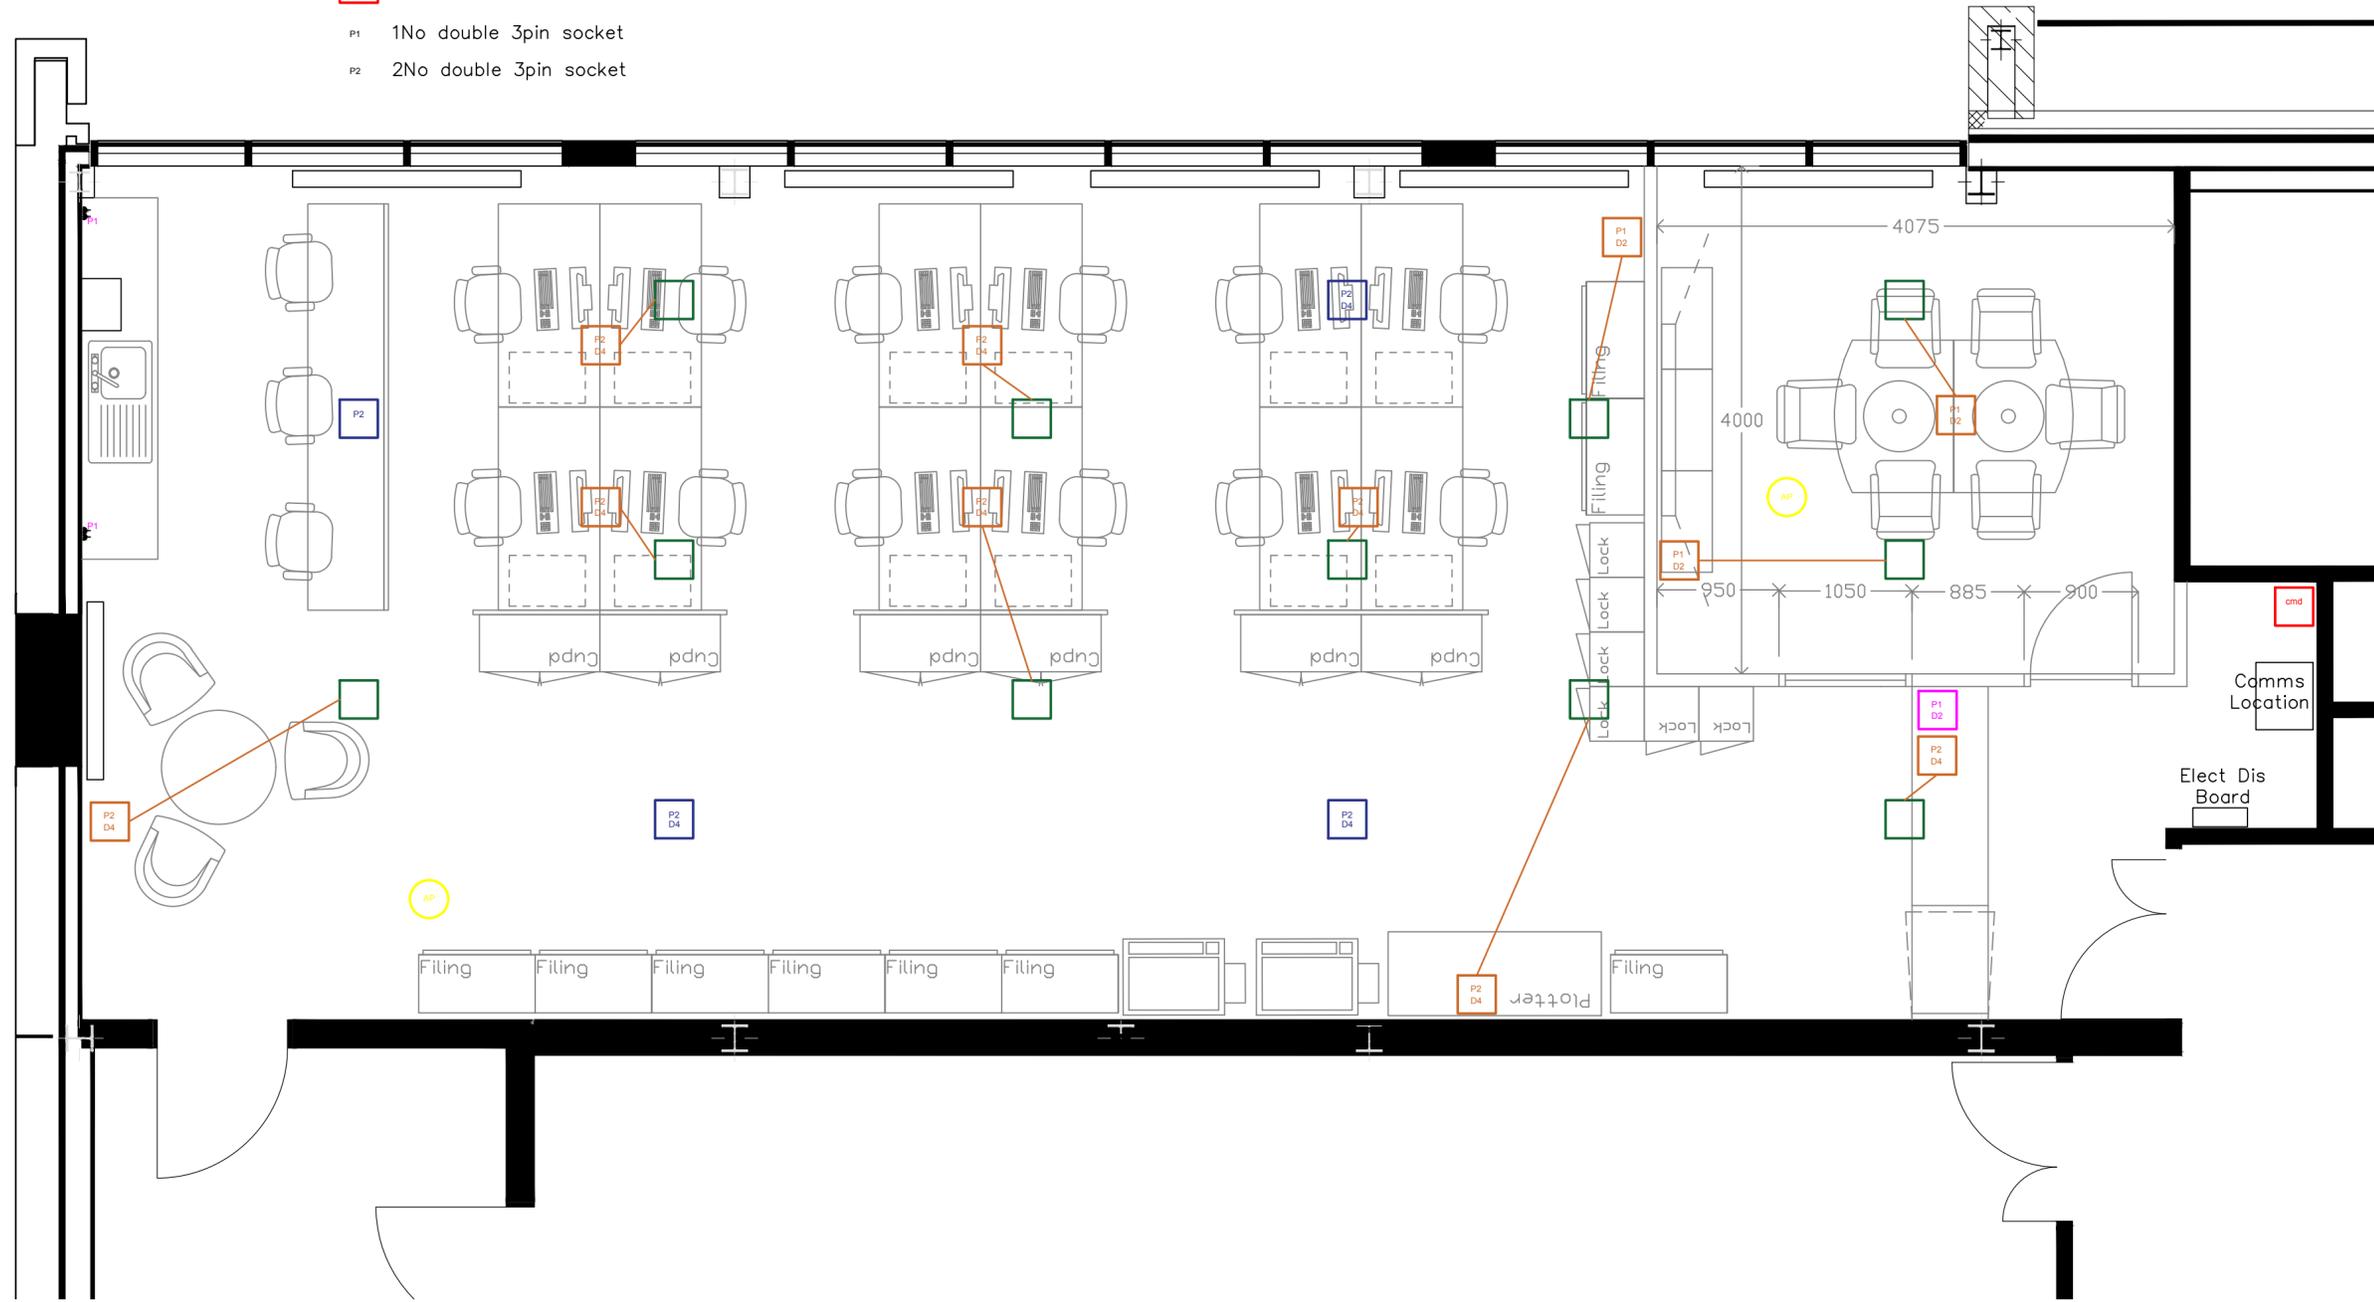

rev	date	description

**Hartnell Taylor Cook**  
LLP

**Hartnell Taylor Cook LLP**  
Somerset House,  
18 Canynge Road,  
Bristol.  
BS8 3JX  
Tel: 0117 923 9234  
Fax: 0117 923 9237  
Email : info@htc.uk.com  
Web: www.htc.uk.com

client:  
Maritime & Coastguard Agency

property:  
First Floor  
Oceansgate, Plymouth

title:  
Proposed Power & Data Layout

drawn	checked
date April 2018	size A2
scale 1:100	
number AL.03	rev A