


NOTES:
**Do not scale dimensions.
 If in doubt, please ask!**

- DEMOLITIONS:**
- SINGLE SKIN BRICKWORK
 - STUD WALL
 - DOUBLE SKIN BRICKWORK
 - TILE WALL FINISH
 - ACRYLIC PANEL WALL FINISH
 - POSSIBLE LOAD BEARING WALL
 - AREA TO BE EXCAVATED FOR SPA AND BALANCE TANK
 - AREA OF FLOOR SCREED TO BE REMOVED FOR UNDERFLOOR HEATING
- P/C-PASTERBOARD CEILING
 S/C-SUSPENDED CEILING
 V/F-VINYL FLOORING
 L/F-LAMINATE FLOORING
 C/T-CARPET TILE
- ➔ ACCESS POINT
- TEMPORARY FULL HEIGHT SCREEN

Existing Layout & Demolitions 1:50

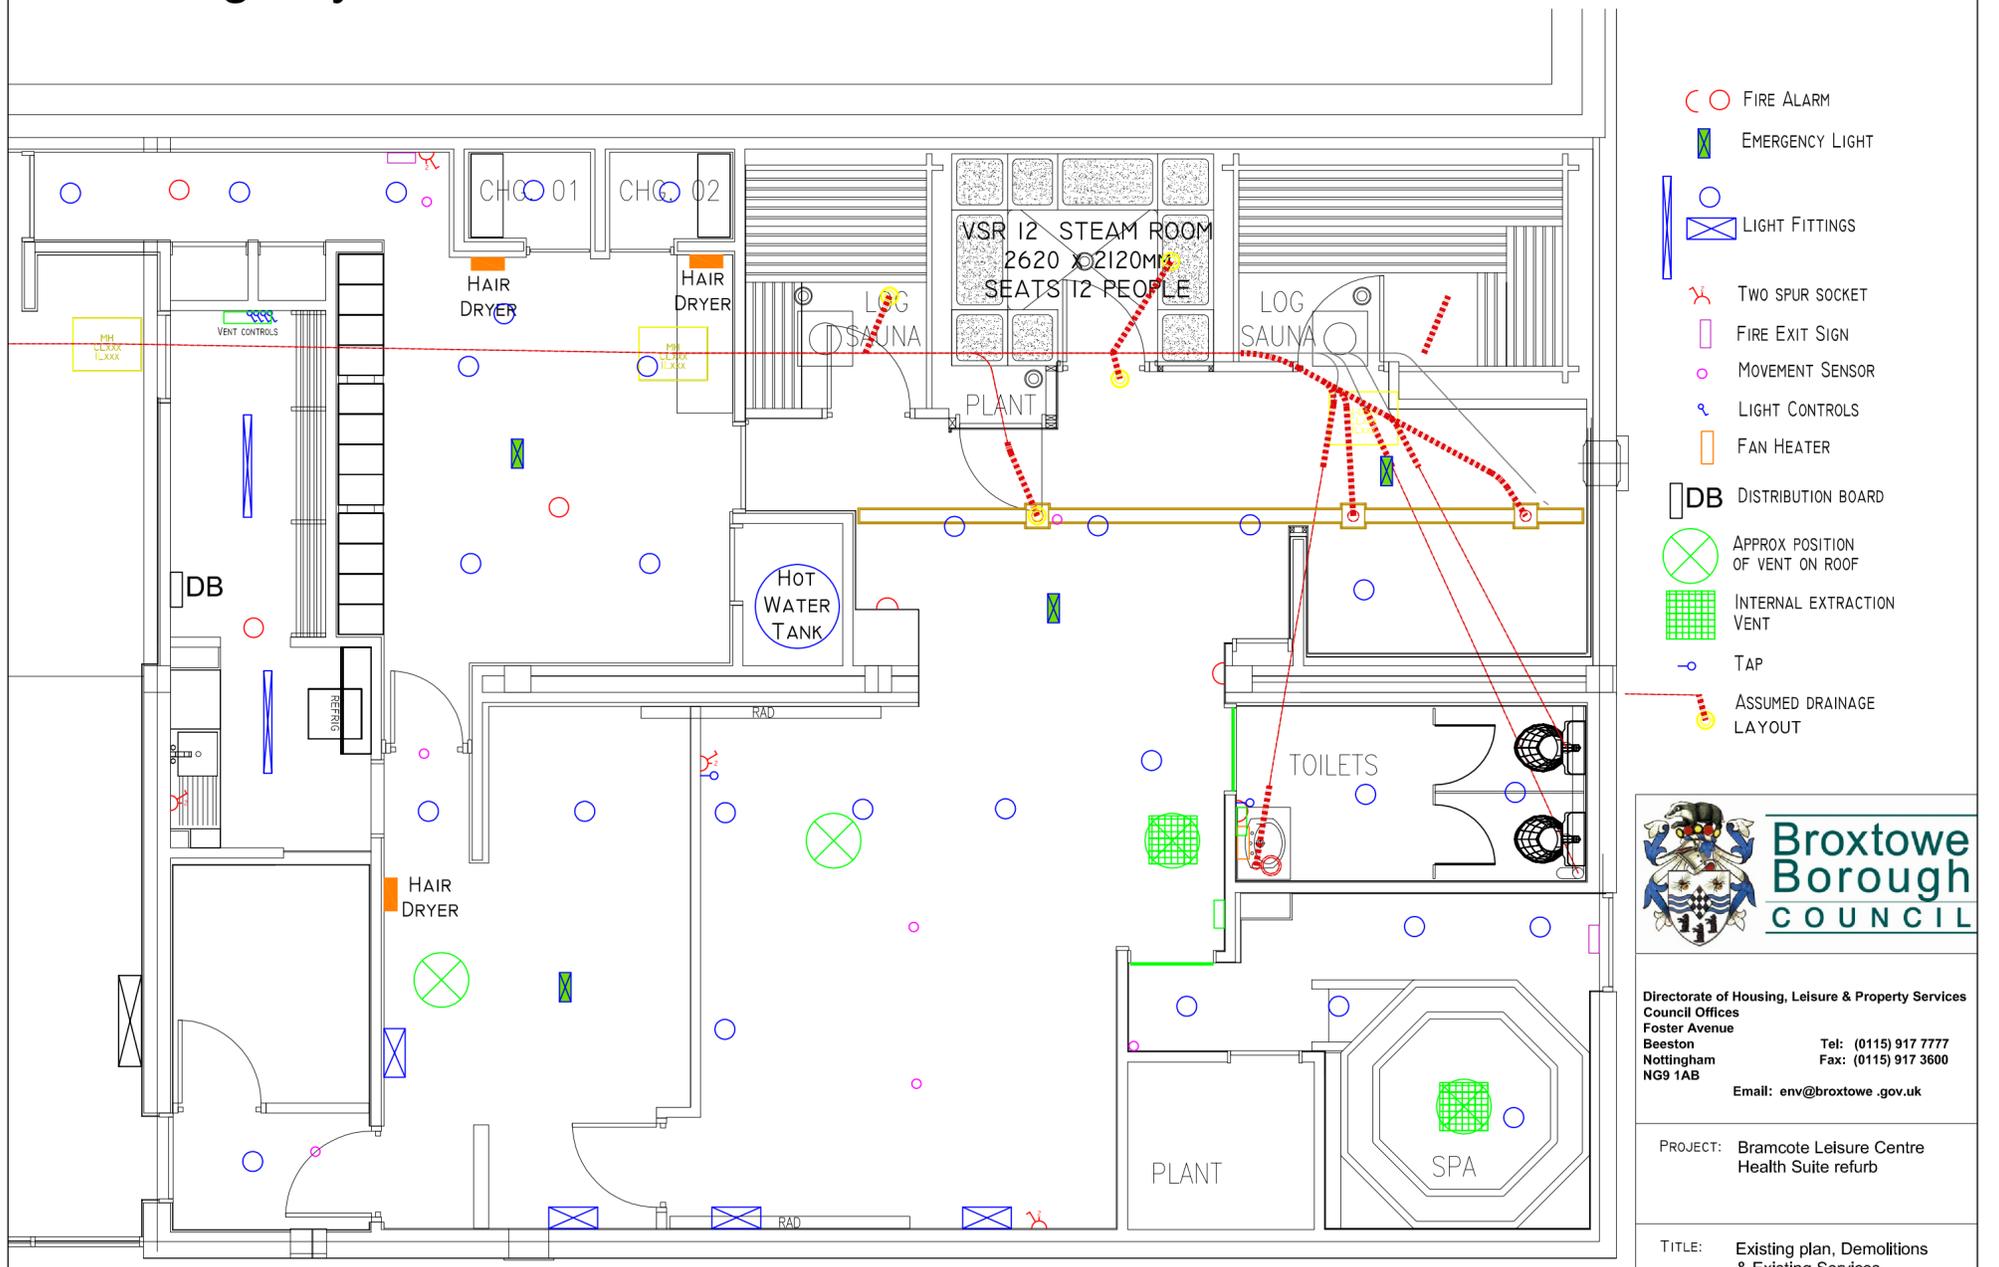

- FIRE ALARM
- ▭ EMERGENCY LIGHT
- ▭ LIGHT FITTINGS
- Y TWO SPUR SOCKET
- ▭ FIRE EXIT SIGN
- MOVEMENT SENSOR
- LIGHT CONTROLS
- ▭ FAN HEATER
- DB DISTRIBUTION BOARD
- ⊗ APPROX POSITION OF VENT ON ROOF
- ▭ INTERNAL EXTRACTION VENT
- TAP
- ASSUMED DRAINAGE LAYOUT



Directorate of Housing, Leisure & Property Services
 Council Offices
 Foster Avenue
 Beeston
 Nottingham
 NG9 1AB
 Tel: (0115) 917 7777
 Fax: (0115) 917 3600
 Email: env@broxtowe.gov.uk

PROJECT: Bramcote Leisure Centre Health Suite refurb

TITLE: Existing plan, Demolitions & Existing Services

SCALE: 1:50 DATE: 21/10/2016

DRAWN: SG CHECK: KJ SIZE: A2

DWG No: CW17.001.003

Existing Services 1:50