




*Building Plan*

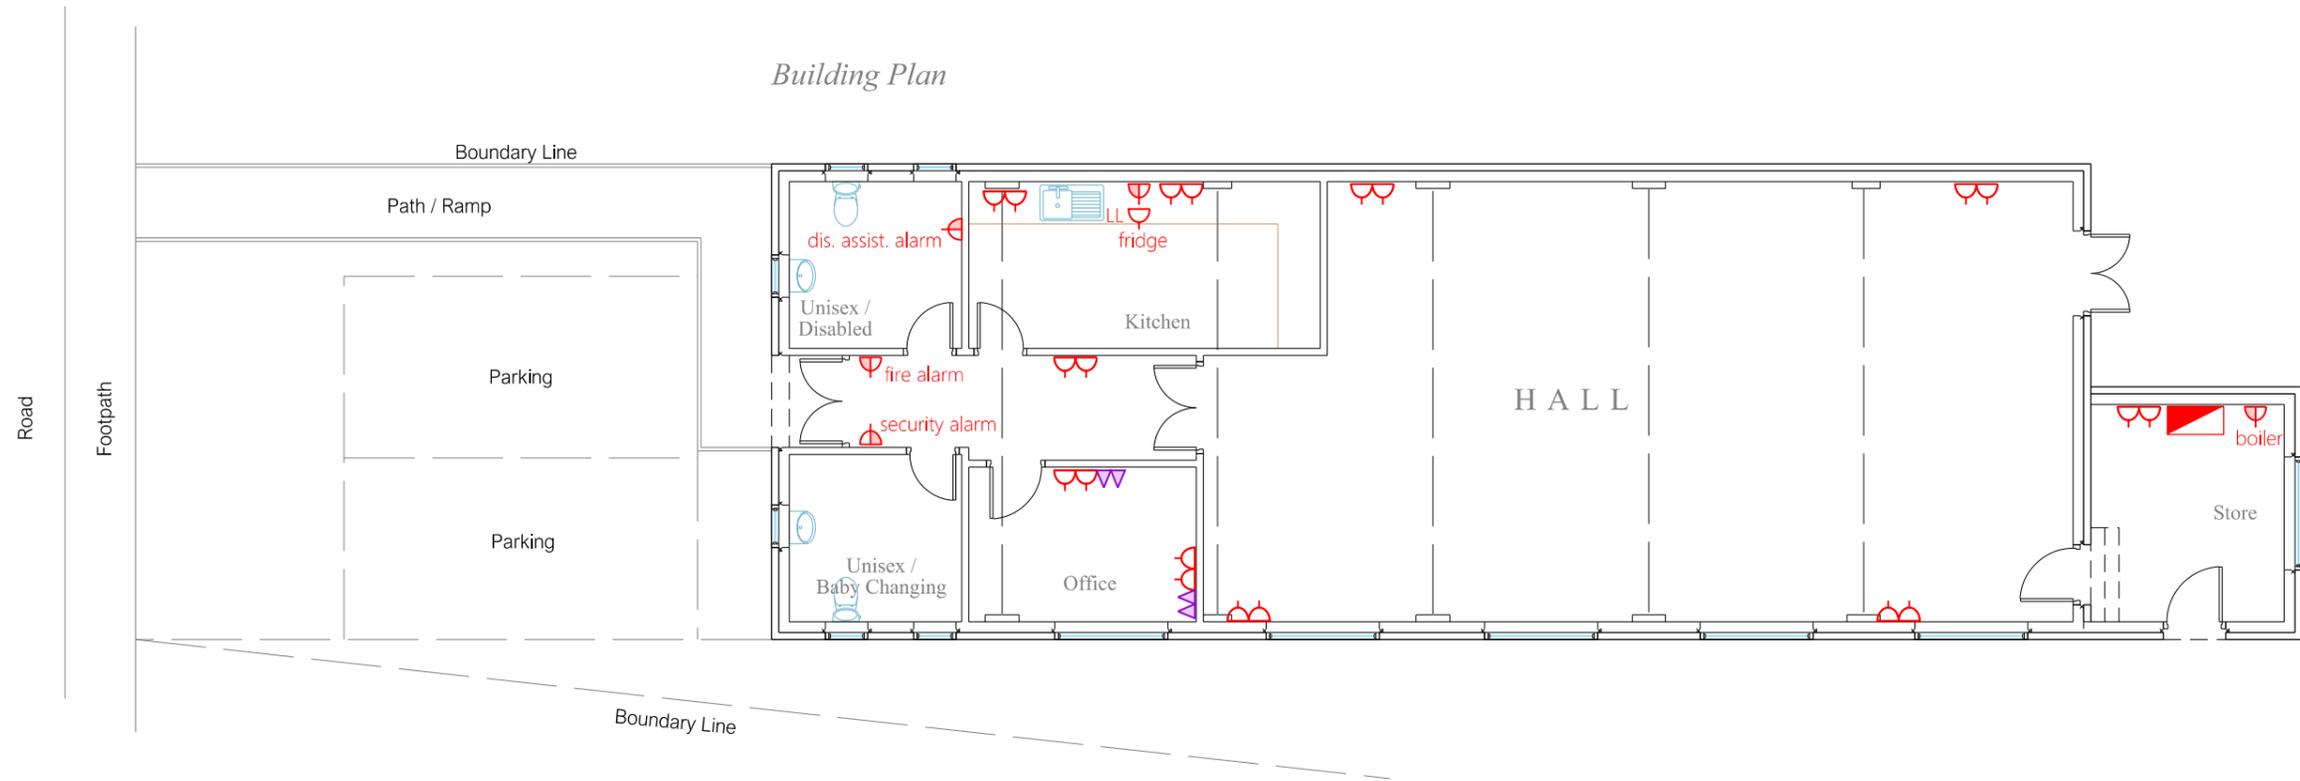

*Front Elevation*

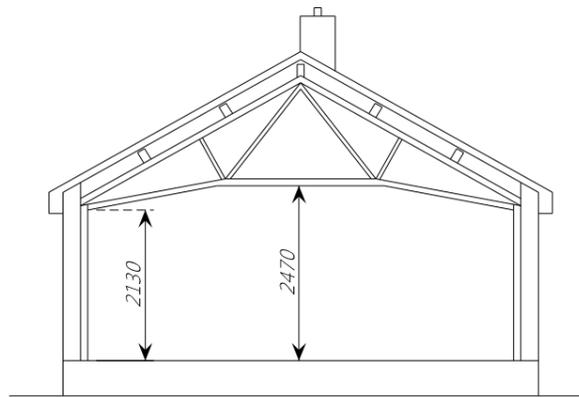

*Section*

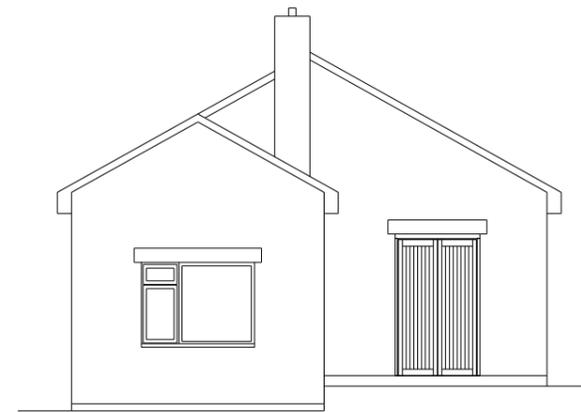

*Rear Elevation*

Scale 1:100 at A3



Scale applies to buildings only.  
All installation positioning is arbitrary.

**LEGEND**

-  Distribution Board
-  13A twin switched socket
-  13A single switched socket at low level
-  switched fused connection unit
-  RJ45 data point

Rev.	Date	Details	By
1	20/12/2018	for comment	C.C.

Rev0 blank : Rev1 for comment  
Rev2 for construction : Rev3 as fitted

Client  
**Central Swindon North Parish Council**  
Pinetrees Community Centre  
32 The Circle, Pinehurst, Swindon. SN2 1QR

Project  
**32 The Circle, Pinehurst**

Building plans supplied by:  
**Home Plan Design Ltd.**  
27B High Street, Highworth, Wilts. SN6 7AG

Drawing Title  
*Electrical Services*

**POWER & DATA**

*for comment*

Project No. <b>9112</b>	Drawing No. <b>E01</b>	Revision <b>1</b>
Scale 1:100 @ A3	Drawn A.T.	Chkd. C.C.
	Date 20/12/2018	

**Affleck Group Services**  
ELECTRICAL MECHANICAL ENERGY COMMUNICATIONS

Unit 10a, The Oppenheimer Centre, Greenbridge Rd, SWINDON, SN3 3LH  
Tel: 01793 533222 Fax: 01793 533215 www.affleckelectrical.co.uk