


Revisions
 A 04.07.2017. Additional smoke detectors, fire alarm call points added to corridor & circulation areas
 B 17.07.2017. Air Cooling to Offices omitted.
 C 02.08.2017 Drg updated

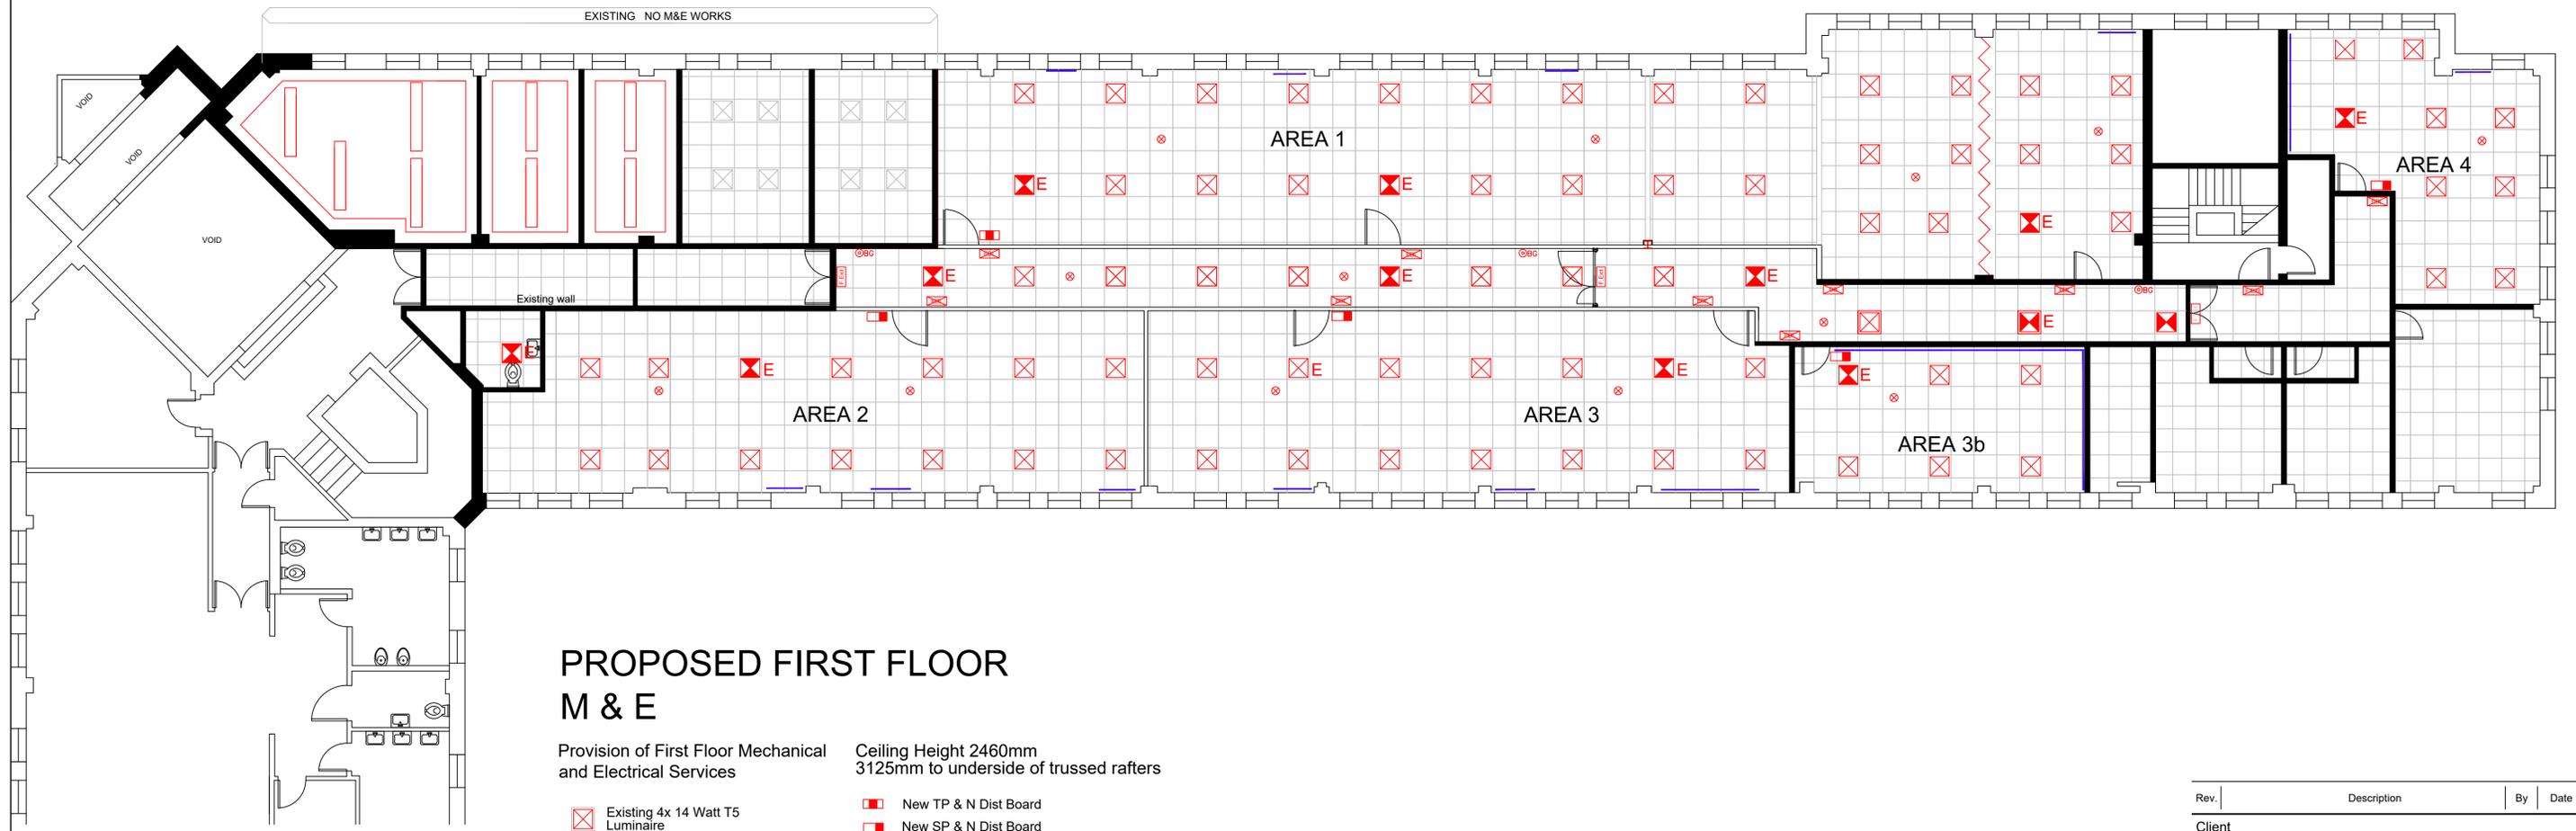

PROPOSED FIRST FLOOR M & E

Provision of First Floor Mechanical and Electrical Services

Ceiling Height 2460mm
3125mm to underside of trussed rafters

-  Existing 4x 14 Watt T5 Luminaire
-  Relocated Existing 4x 14 Watt T5 Luminaire
-  New 3hour duration emergency Luminaire
-  New 3hour duration Fire Exit
-  Fire Alarm break glass alarm call point
-  Fire Alarm ,Smoke Detector
-  Existing Fire Exit
-  Electric Door Lock
-  Existing Trunking
-  New TP & N Dist Board
-  New SP & N Dist Board
-  Existing Dist Board

Rev.	Description	By	Date
------	-------------	----	------

Client
Maritime Coastguard Agency

Project
**Crosskill House
 Beverley**

Drawing Title
First Floor Plan M&E Proposals

Drawing No. **LEBS0789/M&E /02**

Scale **1:50 @ A1** Original Sheet Size A1

Drawing Status	
Drawn JD	Checked
Date 06/17	Rev. C