


Proposed First Floor Layout

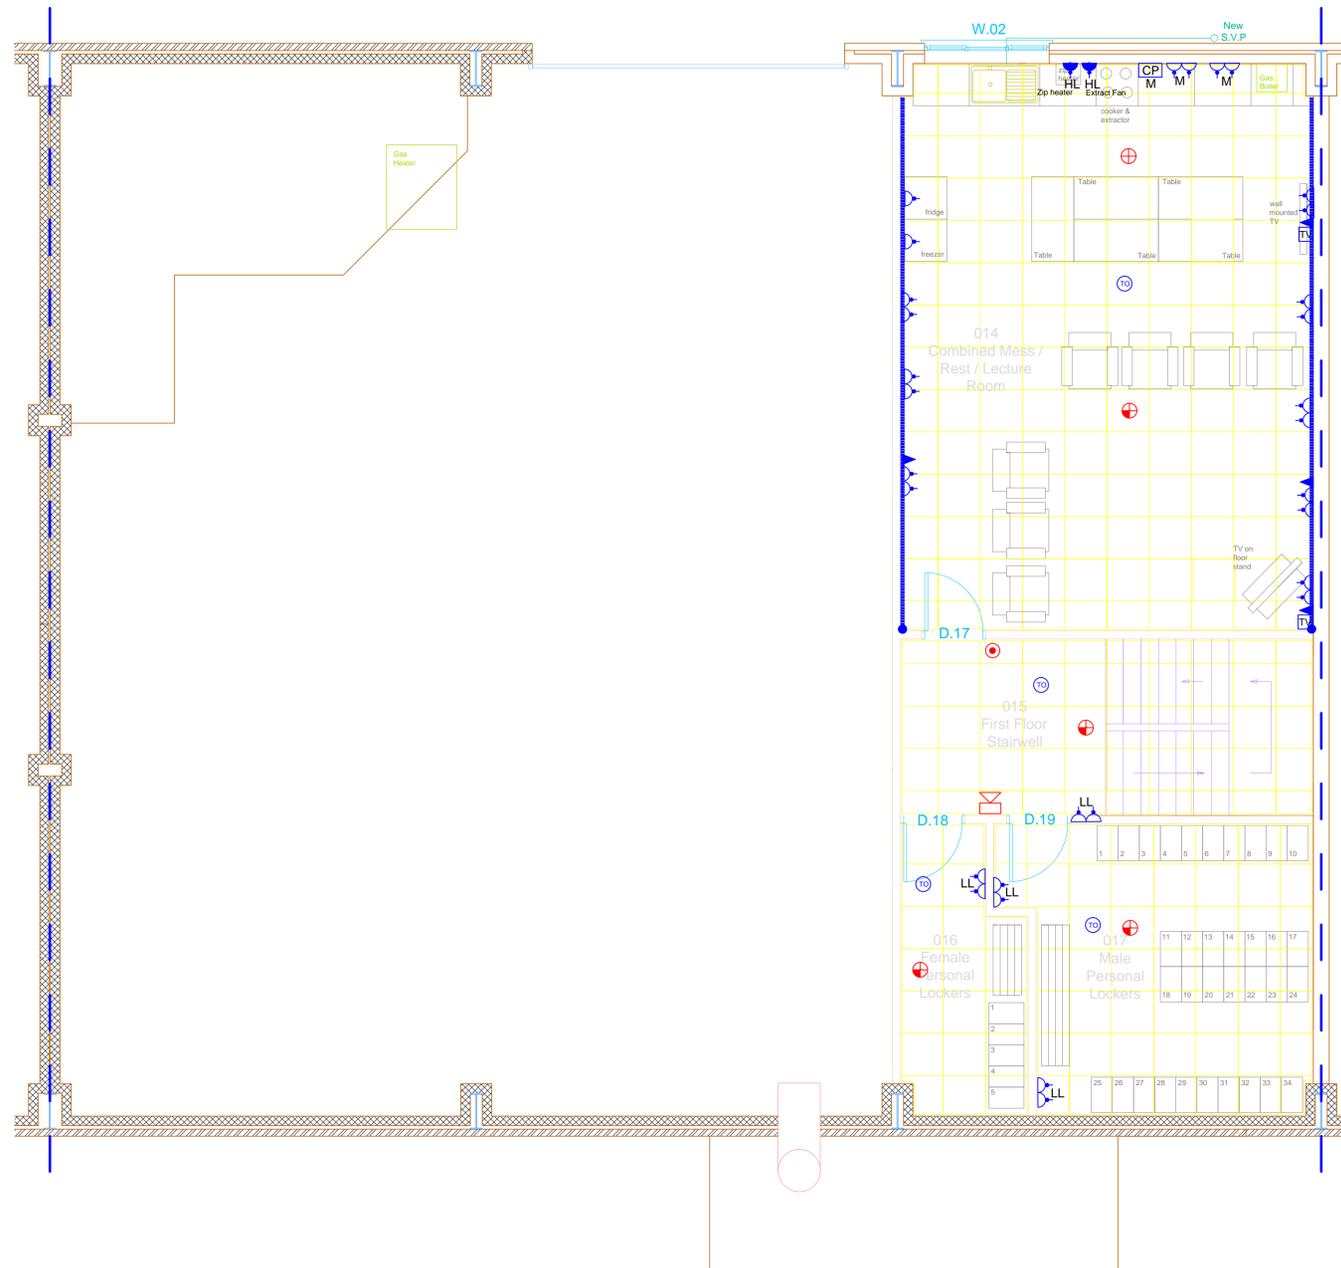

Note:
These drawings are the copyright of
D&d Building Services Consulting
Engineers Ltd. and may only be copied
with prior permission.

All information is indicative only and
must be verified on site by the
contractor.

It is the responsibility of the Contractor to
produce fully co-ordinated and
working detailed drawings

Power Legend	
Symbol	Description
[Symbol]	Distribution Boards location
[Symbol]	Switched Fused Spur
[Symbol]	Unswitched Fused Spur
[Symbol]	Twin Switched Socket
[Symbol]	Switched Single Socket
[Symbol]	Twin Data Outlet
[Symbol]	Telephone Outlet
[Symbol]	Isolator (N=rating, T=Type SP&N or TP&N)
[Symbol]	Cooker point
[Symbol]	Hand Dryer
[Symbol]	Shaver point
[Symbol]	Power Supply Unit
[Symbol]	Disabled Alarm lamp Buzzer Unit
[Symbol]	Disabled Alarm Pull Cord with reassurance light
[Symbol]	Disabled Alarm Reset Button
[Symbol]	Television Point
[Symbol]	Electric Shower
[Symbol]	Dado Trunking with power and data outlets
[Symbol]	Dado Trunking rise to ceiling Void
[Symbol]	HL Denotes High Level
[Symbol]	LL Denotes Low Level
[Symbol]	DD Denotes Dado level/above desk worktop
[Symbol]	CV Denotes Ceiling Void

Intruder Alarm & CCTV Legend	
Symbol	Description
[Symbol]	Surface mounted magnetic controller
[Symbol]	Dual technology motion detector
[Symbol]	Intruder alarm set pushbutton
[Symbol]	Intruder alarm KP75 keypad reader
[Symbol]	Intruder alarm control panel
[Symbol]	CCTV camera
[Symbol]	CCTV monitor

Fire Alarm Legend	
Symbol	Description
[Symbol]	Fire alarm panel
[Symbol]	Fire alarm breakglass call point
[Symbol]	Optical Smoke Detector
[Symbol]	Optical Smoke Detector with ceiling recessed remote indicator
[Symbol]	Optical Smoke Detector with Sounder Base
[Symbol]	Heat Detector
[Symbol]	Fire alarm sounder with beacon
[Symbol]	Fire alarm sounder
[Symbol]	Zenon Beacon
[Symbol]	Fire Alarm Interface

Access Control Legend	
Symbol	Description
[Symbol]	Exit push button
[Symbol]	PAC access control
[Symbol]	PA speaker recessed
[Symbol]	PA speaker surface mounted
[Symbol]	Turnout system speaker recessed
[Symbol]	Turnout System speaker surface mounted
[Symbol]	Turnout System beacon surface mounted
[Symbol]	Green breakglass access control release
[Symbol]	Intercom with camera
[Symbol]	Intercom with camera Master Unit
[Symbol]	PAC system power supply unit
[Symbol]	PAC system power supply unit surface mounted above ceiling
[Symbol]	Maglock

TO	03.10.17	Tender Issue	AG
Rev	Date	Description	Initials

D&d
Building Services Consulting Engineers Ltd
28 Market Place, Kegworth
Derby, DE74 2EE
Tel: 01509 670100
Fax: 01509 670110

Client
**Derbyshire
Fire & Rescue Service**

Project
Temporary Accomodation

Drawing Title
**Proposed Small Power, Data
& Fire Alarm Layout.
First Floor Level.**

Scale: 1:50@ A1 Date: September 2017

Drawn: AG Checked: RJC

Drawing No.: 17.043/ E / 04 Rev /T0

Tender Issue