




Building Plan

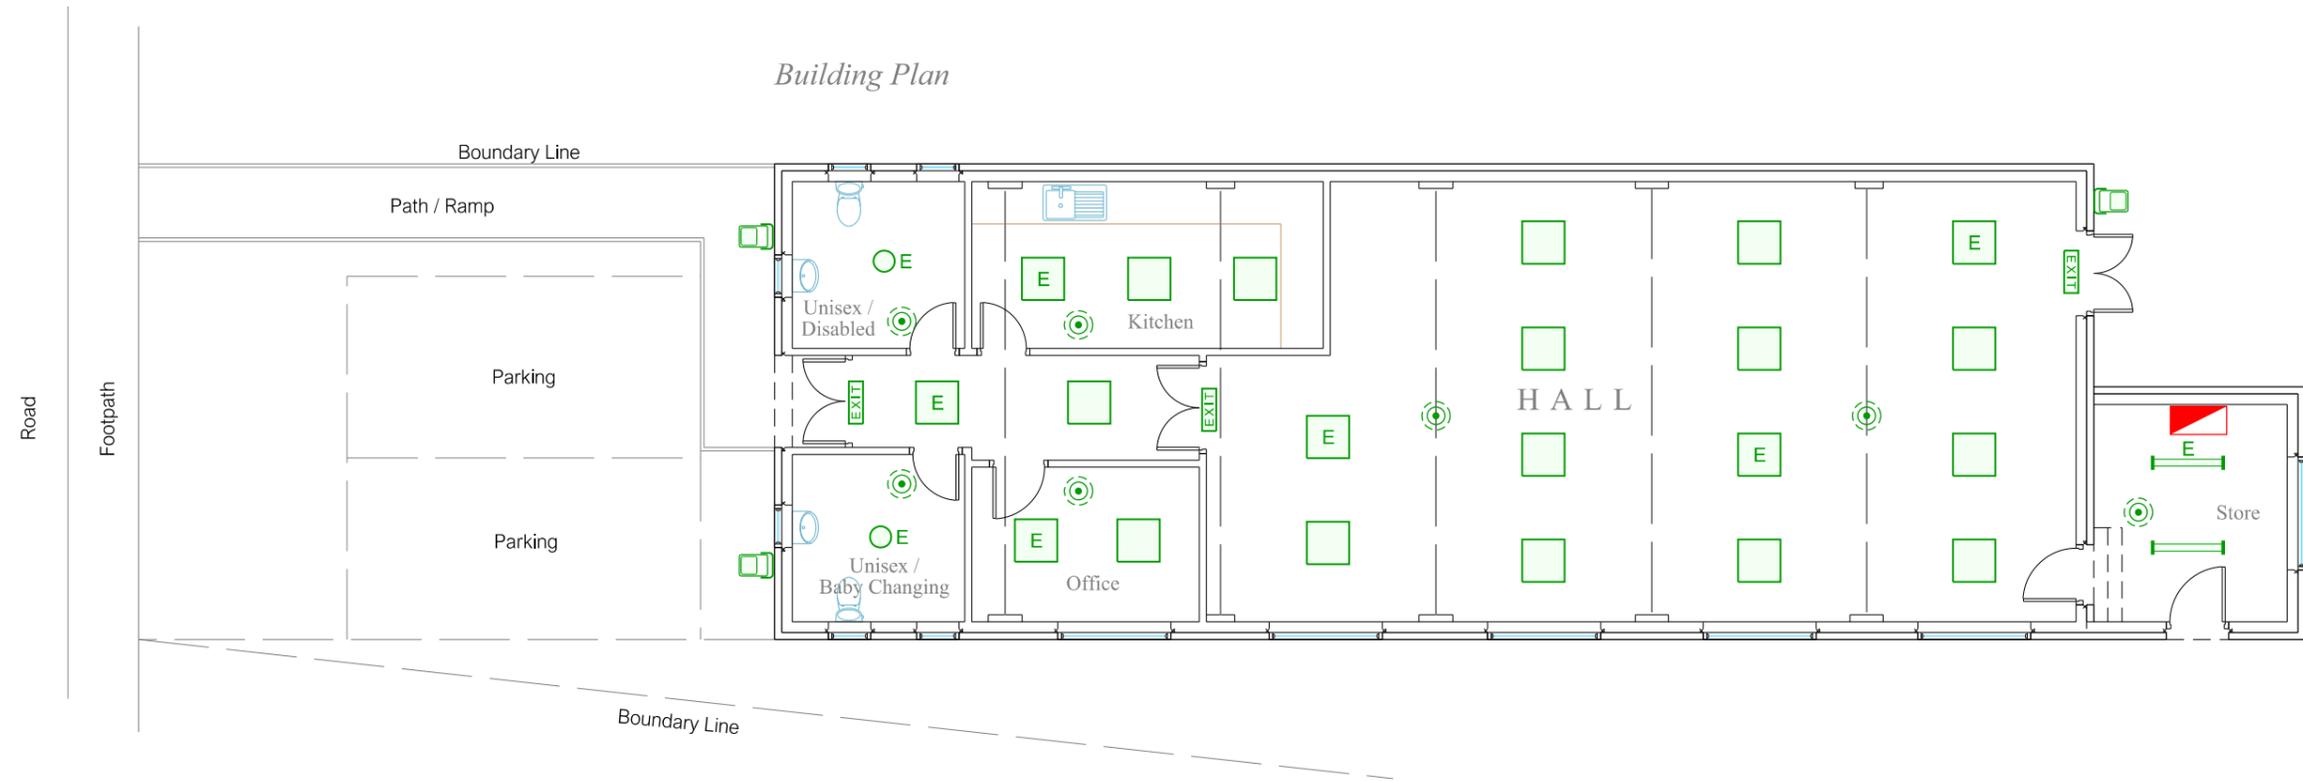

Front Elevation

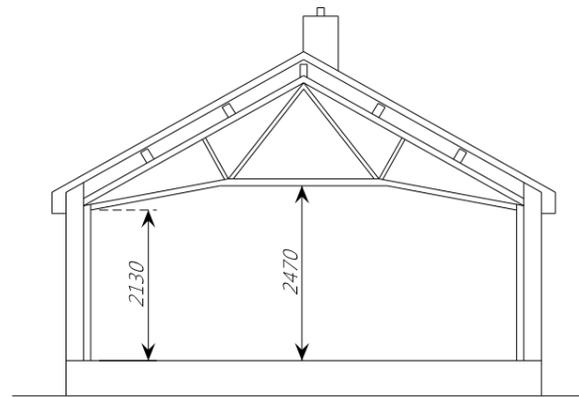

Section

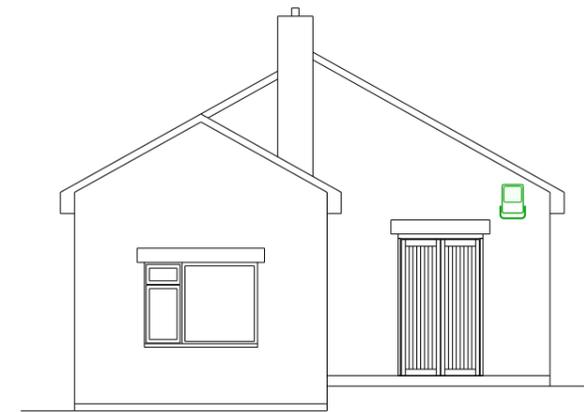

Rear Elevation

Scale 1:100 at A3



Scale applies to buildings only.
All installation positioning is arbitrary.

LEGEND

- LED panel luminaire, 600x600mm
- LED circular luminaire
- 80W LED batten luminaire
- PIR presence detector lighting control
- illuminated emergency exit sign, LED
- 30W LED floodlight, with PIR sensor
- E - indicates emergency fitting

Rev.	Date	Details	By
1	20/12/2018	for comment	C.C.

Rev0 blank : Rev1 for comment
Rev2 for construction : Rev3 as fitted

Client
Central Swindon North Parish Council
Pinetrees Community Centre
32 The Circle, Pinehurst, Swindon. SN2 1QR

Project
32 The Circle, Pinehurst

Building plans supplied by:
Home Plan Design Ltd.
27B High Street, Highworth, Wilts. SN6 7AG

Drawing Title
Electrical Services

LIGHTING

for comment

Project No. 9112	Drawing No. E02	Revision 1
Scale 1:100 @ A3	Drawn A.T.	Chkd. C.C.
	Date 20/12/2018	

Affleck Group Services
ELECTRICAL MECHANICAL ENERGY COMMUNICATIONS

Unit 10a, The Oppenheimer Centre, Greenbridge Rd, SWINDON, SN3 3LH
Tel: 01793 533222 Fax: 01793 533215 www.affleckelectrical.co.uk