


**NOTES**

Please refer to ABP & Southern Water information regarding public sewer diversion & build over works.

Proposed private drainage layout is indicative only and to be fully investigated and confirmed on site by contractor prior to construction.

Soakaway design and location subject to infiltration test - contractor to undertake and confirm.

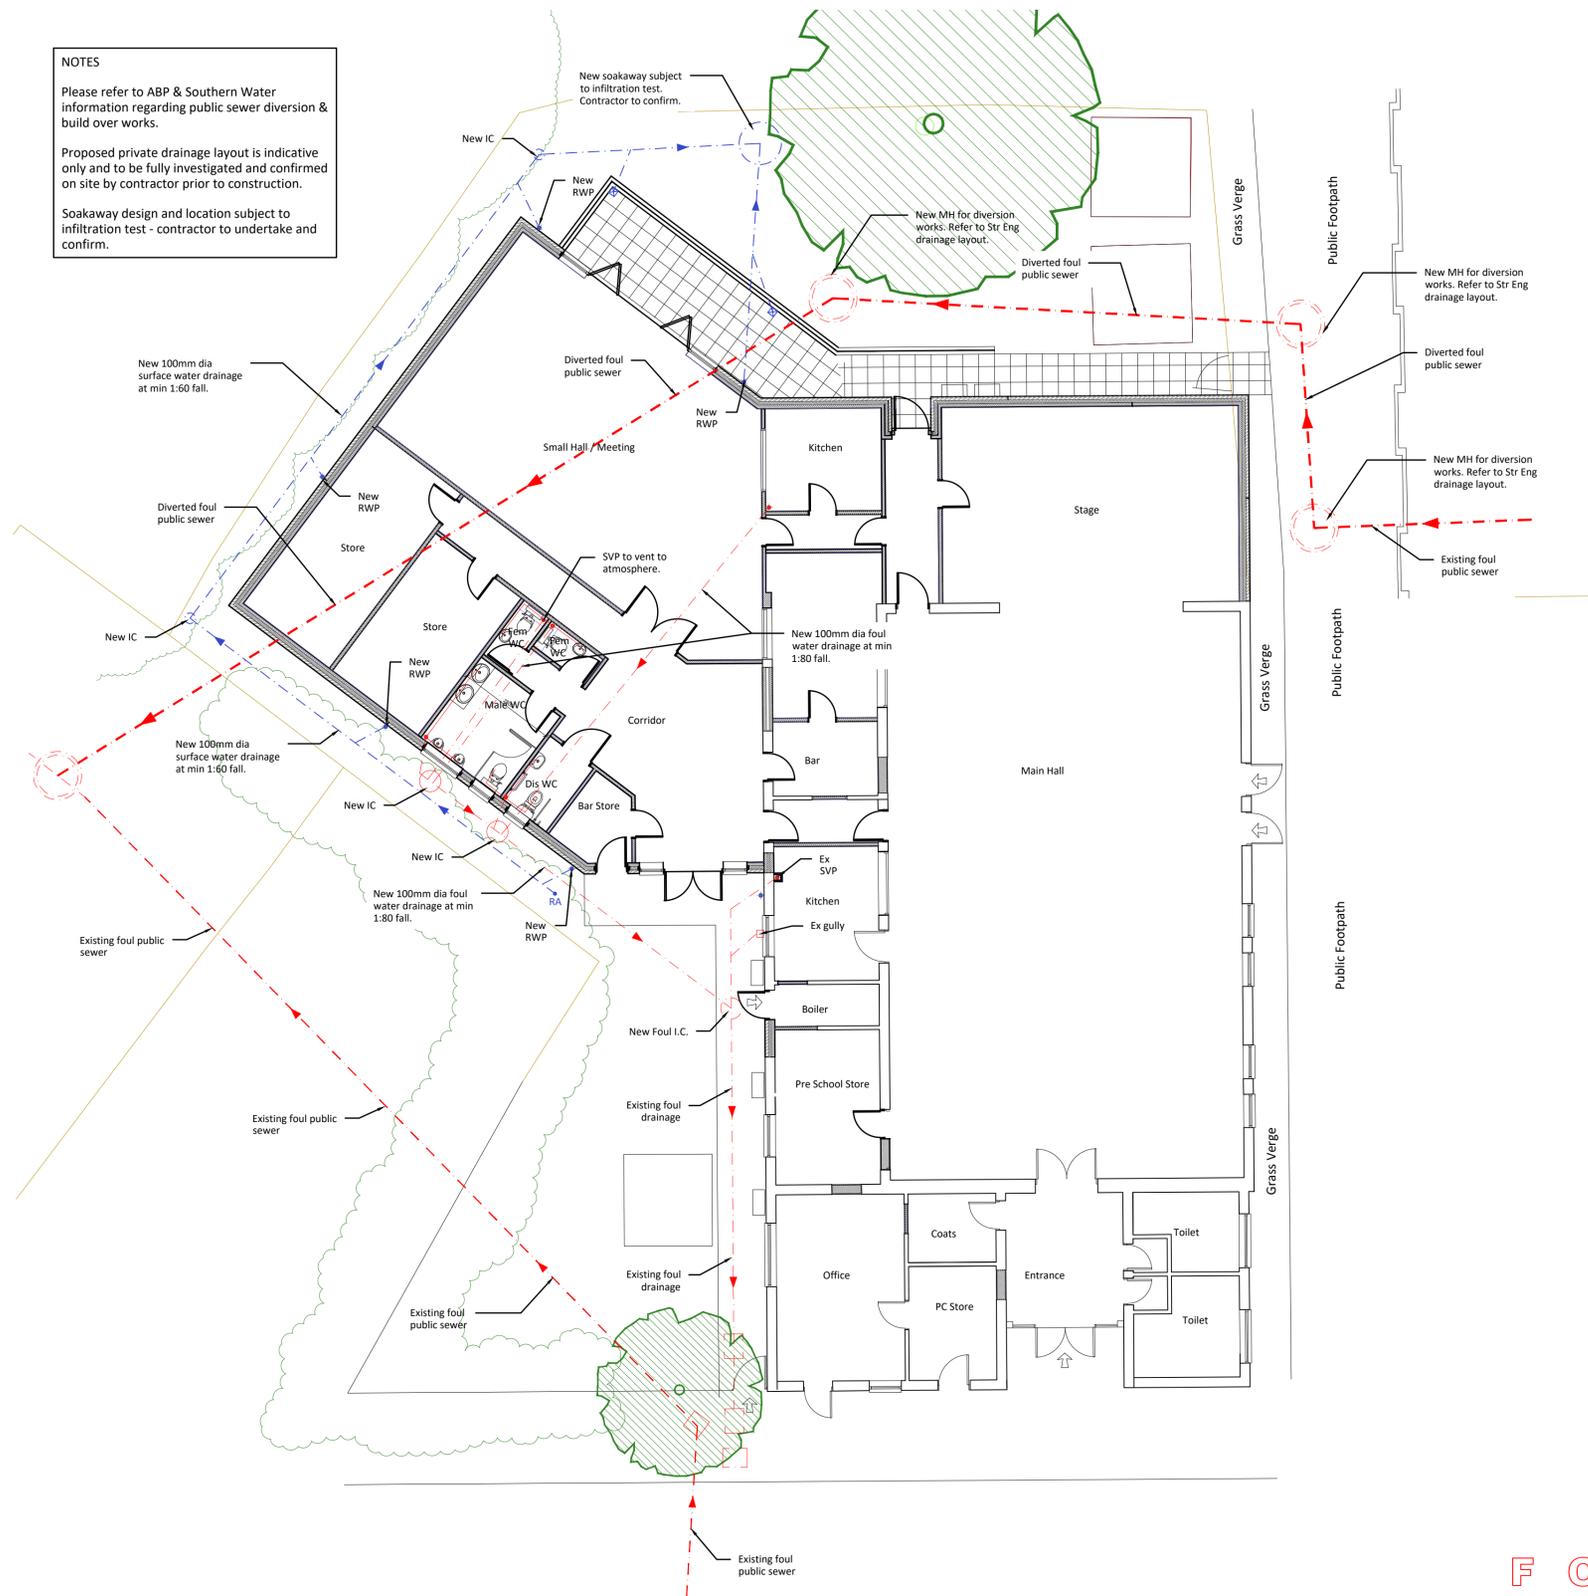

FOR APPROVAL

Site Plan  
As Proposed

1:100

rev.	description	date	chkd.
------	-------------	------	-------

client :  
**Leybourne Parish Council**

project :  
**Extension & Alterations at Leybourne Village Hall**

drawing title :  
**Site Plan As Proposed**

**fulkers**™  
 property and construction consultants  
 willmill house // 129-130 willmill street // gravesend // kent // da12 1bl  
 info@fulkers.co.uk // www.fulkers.co.uk // 01474 369175

drawn: AS	chkd: SP	date: March 2018
-----------	----------	------------------

status: **Preliminary** scale: 1:100 @ A1

proj no : **17-1607**

drg no : <b>01</b>	rev no:
--------------------	---------