


Existing hedge removed
and ground levels
reduced to accommodate
path behind pavilion

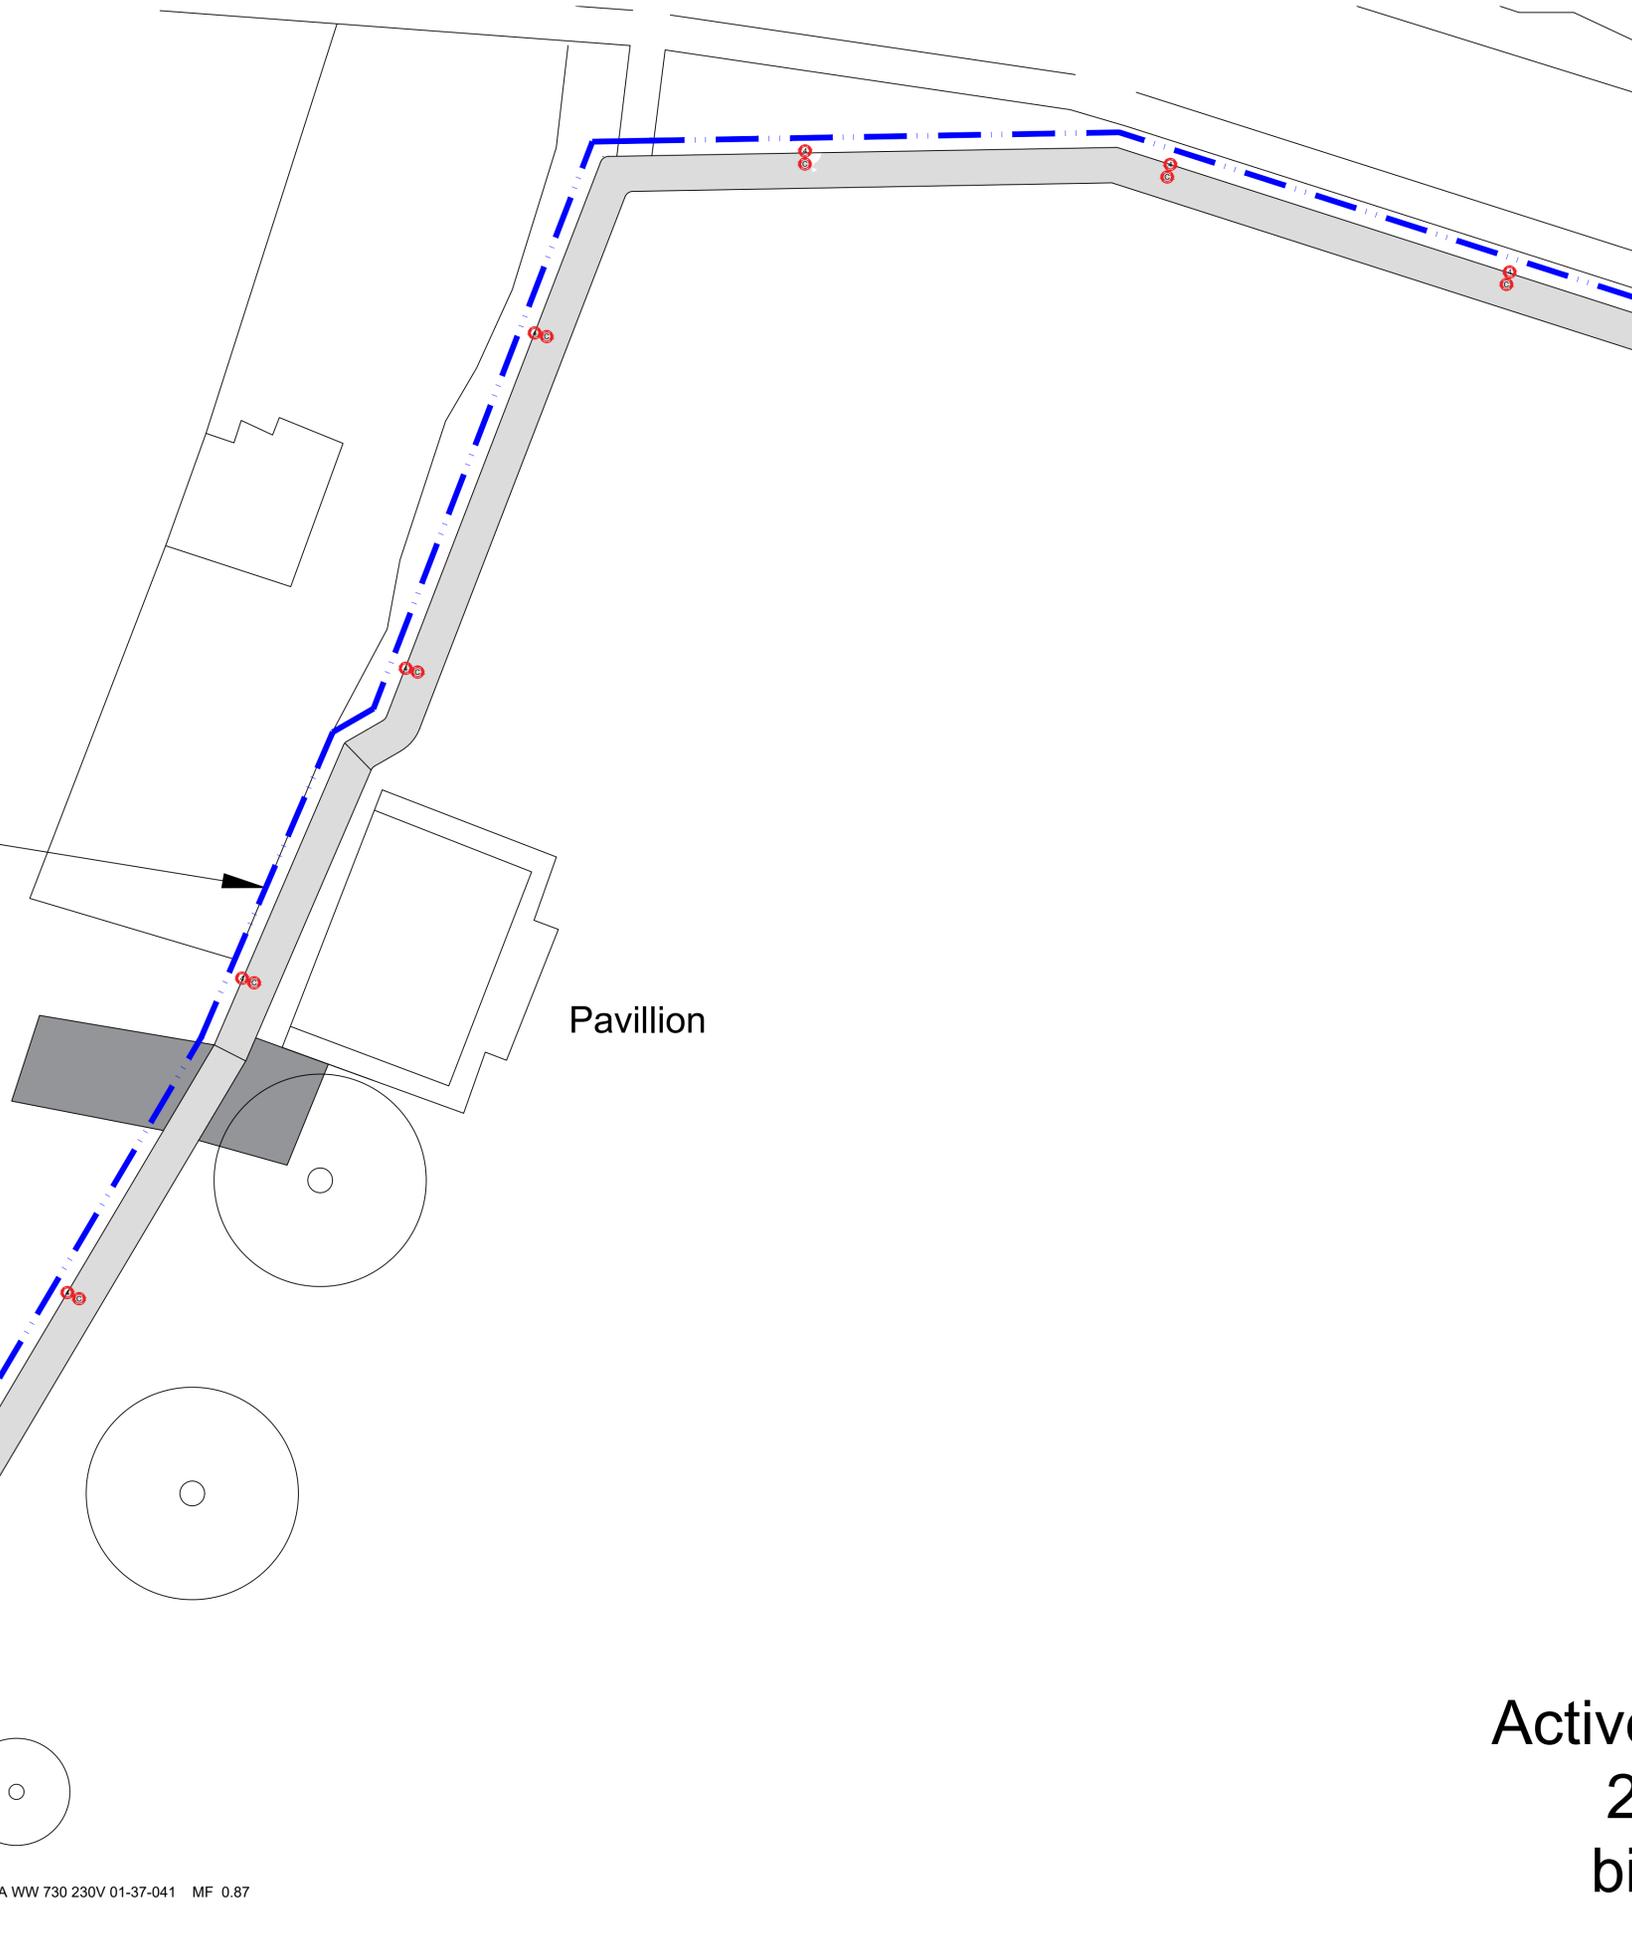

- Legend
- B Luminaire B
 - C Luminaire C
 - 4 4M Column

— — — — — Ducting Route installed under previous contract.

Luminaire Data
 Luminaire B PHAROS 5119 Asymmetrical 8 LEDs 350mA WW Cylindrical, PC, Sm Lamp 8 LEDs MF 0.87
 Luminaire C AXIA 3.1 5296 Integrated lenses Rear louvers 8 OSLO SQUARE Lamp 8 OSLO SQUARE GIANT@300mA WW 730 230V 01-37-041 MF 0.87

Rev	Revision Detail	Date
T1	Revised to Urbis lighting redesign 28th Feb 2022	16.04.22



Southeast Electrical Solutions Ltd
 11 Amanda close
 Bexhill-on-Sea
 East Sussex
 TN40 2TB

TEL: 07802 166168
 EMAIL: info@seelectricalsolutions.co.uk
 WEB: www.seelectricalsolutions.co.uk

CLIENT:
Hailsham Town Council

PROJECT:
Active Circuit Western Recreation Ground Hailsham

TITLE:
Lighting layout Sheet 1 of 4

DRAWN	CHECKED	DATE	SCALE
SL	SL	MAR 2020	1:200
DRAWING No.			REVISION
1768 - E - 0200			T1

Active
2
bi