



PROPOSED FOUNDATION AND DRAINAGE LAYOUT
SCALE 1:50

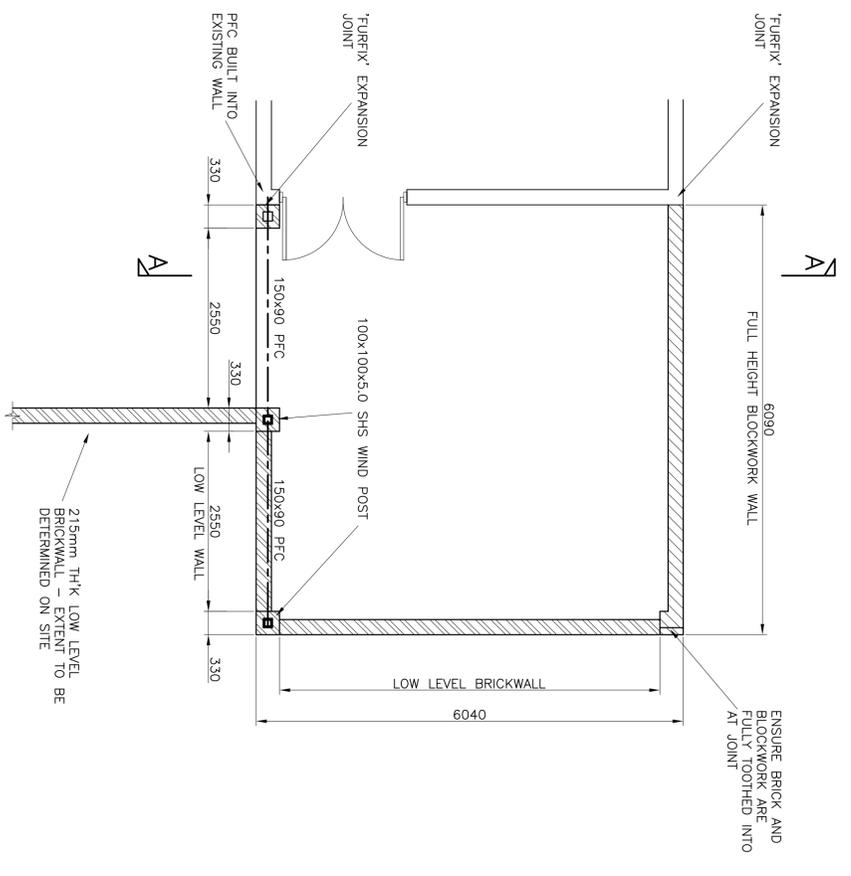

PROPOSED FLOOR PLAN SHOWING BEAMS OVER
SCALE 1:50

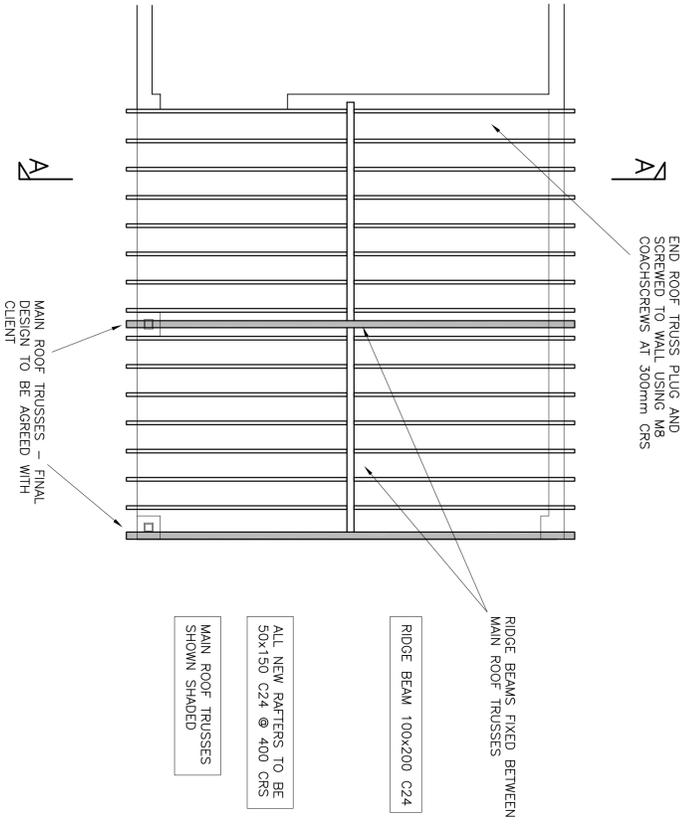

PROPOSED ROOF PLAN
Scale 1:50

REFERENCE DRAWINGS

REV	DATE	REVISION	OR REVIEW

Orange Key
Unit 4, The Colings
120 High Street, Hungerford
Berkshire, RG17 0UJ
E-mail: info@orangekeyltd.co.uk

Client
THE CROFT BUILDING

Project
20 THE CROFT
HUNGERFORD
RG17 0HY

Title
PROPOSED FLOOR PLANS

Scale
AS SHOWN @ A1

Originator
MN

Date
APR 17

Reviewed By

Drawing number
16074/101

Rev.
P1