

This drawing is Copyright © of GVA Grimley Limited.
 Do not scale this drawing.
 All dimensions to be checked on site, schedules and Consultants drawings and details.

FIRE STRATEGY

Third Floor Deck

- Regulation 2.2.2
 Description
 Occupancy load factor
 Occupancy Category
 Risk Rating
 Direction of Travel
- Regulation 2.2.7
 Occupancy Category
 Occupancy Category
 Risk Rating


- Regulation 2.2.2
 Description
 Occupancy load factor
 Occupancy Category
 Risk Rating
 Direction of Travel
- Regulation 2.2.7
 Occupancy Category
 Occupancy Category
 Risk Rating

FIRE ALARM WORKS LOGS


- Fire alarm call point.
- Fire alarm smoke detector.
- Fire alarm audible sander.

All fire alarm works will be carried out in accordance with the Fire Alarm Regulations 2002, the Fire Alarm Code of Practice for Design, Installation, Commissioning and Maintenance of Systems in Non-Domestic Premises, and the Fire Alarm Code of Practice for Design, Installation, Commissioning and Maintenance of Systems in Non-Domestic Premises.

New fire alarm works to interface with existing fire alarm control panel located in ground floor entrance lobby.

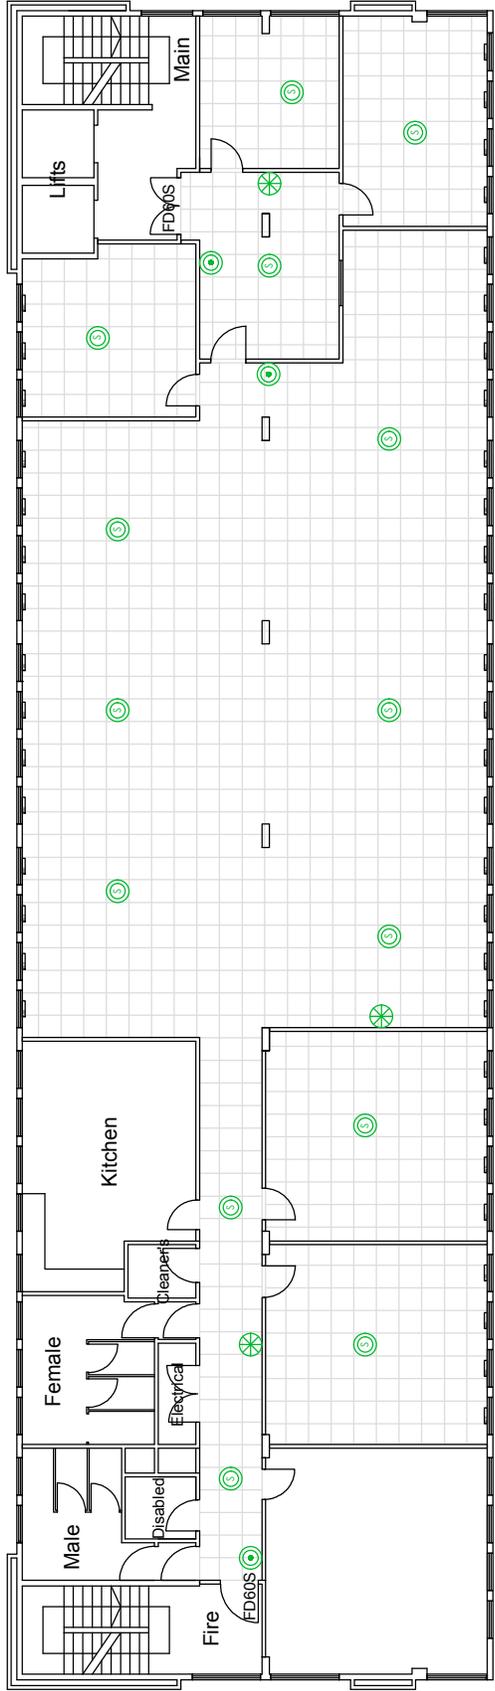

PROPOSED FIRE ALARM SYSTEM

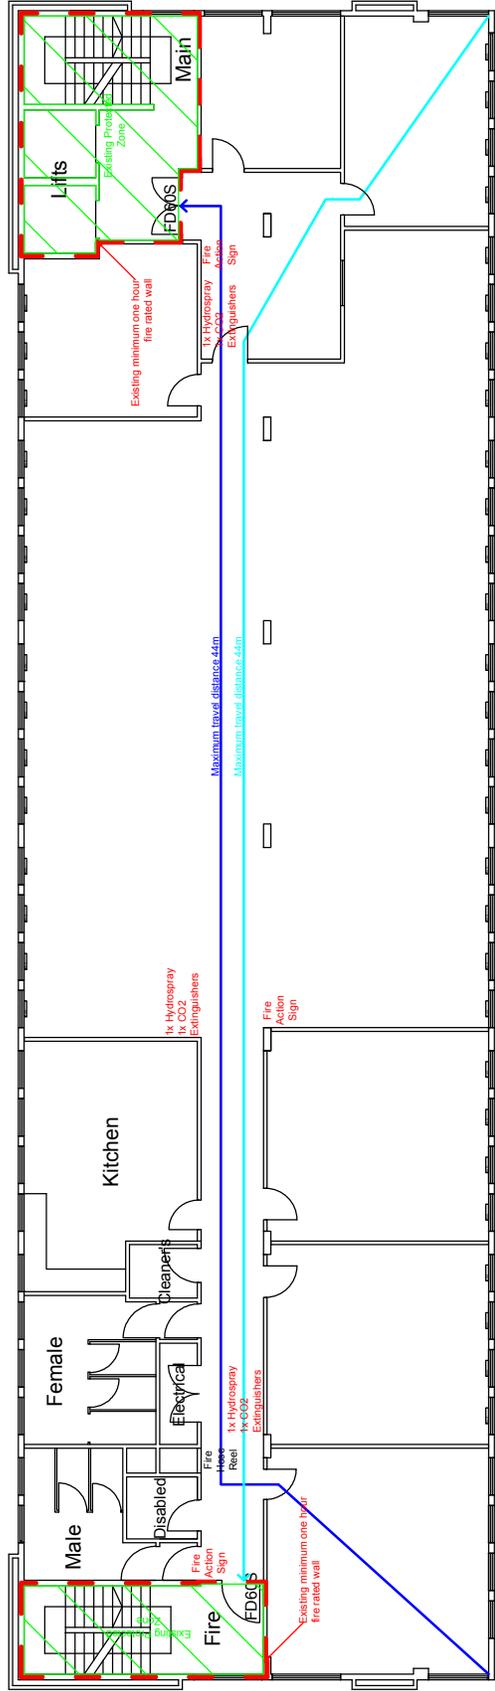

PROPOSED FIRE STRATEGY

By: Revision Details
 Date: 11/06/18

GVA
 Superbrand House, 149 St Vincent Street, Glasgow, G2 5HW
 T: +44 (0) 141 300 8000
 E: enquiries@gva.co.uk
 www.gva.co.uk/scotland

Project Name
 3rd Floor Marine House, Balcarras Quay, Aberdeen
 Internal Alterations - Phase 2

Client
 Maritime & Coastguard Agency

Drawing Title
 Proposed Fire Alarm System
 Proposed Fire Strategy

Scale @ A2
 1:100

Date
 11/06/18

Project No.
 068710797

Drawing No.
 PH2/3

Revision
 -