

- Notes:**
- Do not scale this drawing.
 - This drawing is to be read in conjunction with all other relevant drawing issues and specification.
 - All building materials, components and workmanship is to comply with the appropriate building regulations, British Standards and codes of practice and the appropriate manufacturers recommendations.
 - For all specialist work see relevant drawings.
 - Any discrepancies, errors or omissions are to be reported to the project coordinator for further instructions before commencement of works.
 - The engineer is not responsible for dimensions, except where shown on their drawings. All setting out information, dimensions, etc., shall be calculated from the architect's drawings. For dimensioned layouts of walls see architect's drawings.

LEGEND

- [FAP] FIRE ALARM CONTROL PANEL
- [FIU] FIRE ALARM INTERFACE UNIT
- (So) FIRE ALARM SMOKE DETECTOR, OPTICAL
- (HT) FIRE ALARM HEAT DETECTOR, FIXED RATE
- (So) COMBINED SMOKE DETECTOR & SOUNDER
- (So) COMBINED SMOKE DET. SOUNDER & BEACON
- (HT) COMBINED HEAT DETECTOR & SOUNDER
- (HT) COMBINED SMOKE DET. SOUNDER & BEACON
- (●) FIRE ALARM BREAK GLASS UNIT

T2	TENDER ISSUE. KITCHEN AND STORE WORKS ADDED	BH		20.07.20
T1	TENDER ISSUE	BH		06.03.20
P1	PRELIMINARY ISSUE	JC	CC	01.07.19
Rev	Description	Iss	Chk	Date

Client
Wivesfield Parish Council

Project
Wivelsfield Village Hall

Drawing
Ground Floor Plan - Fire Alarm Layout


Scale @ A1
1:50 This bar is 5cm when printed to scale

TENDER

crofton THE HOPPERS
GOBLANDS FARM BUSINESS CENTRE
CEMETERY LANE
HADLOW
KENT TN11 0LT
T 01732 850440
E kent@crofton-design.com
W www.crofton-design.com

Consulting Engineers
London | Kent | East Sussex

Job No.	Drg. No.	Rev
18206	E-2001	T2
18206-CFN-00-00-DR-E-2001-D4-T2		

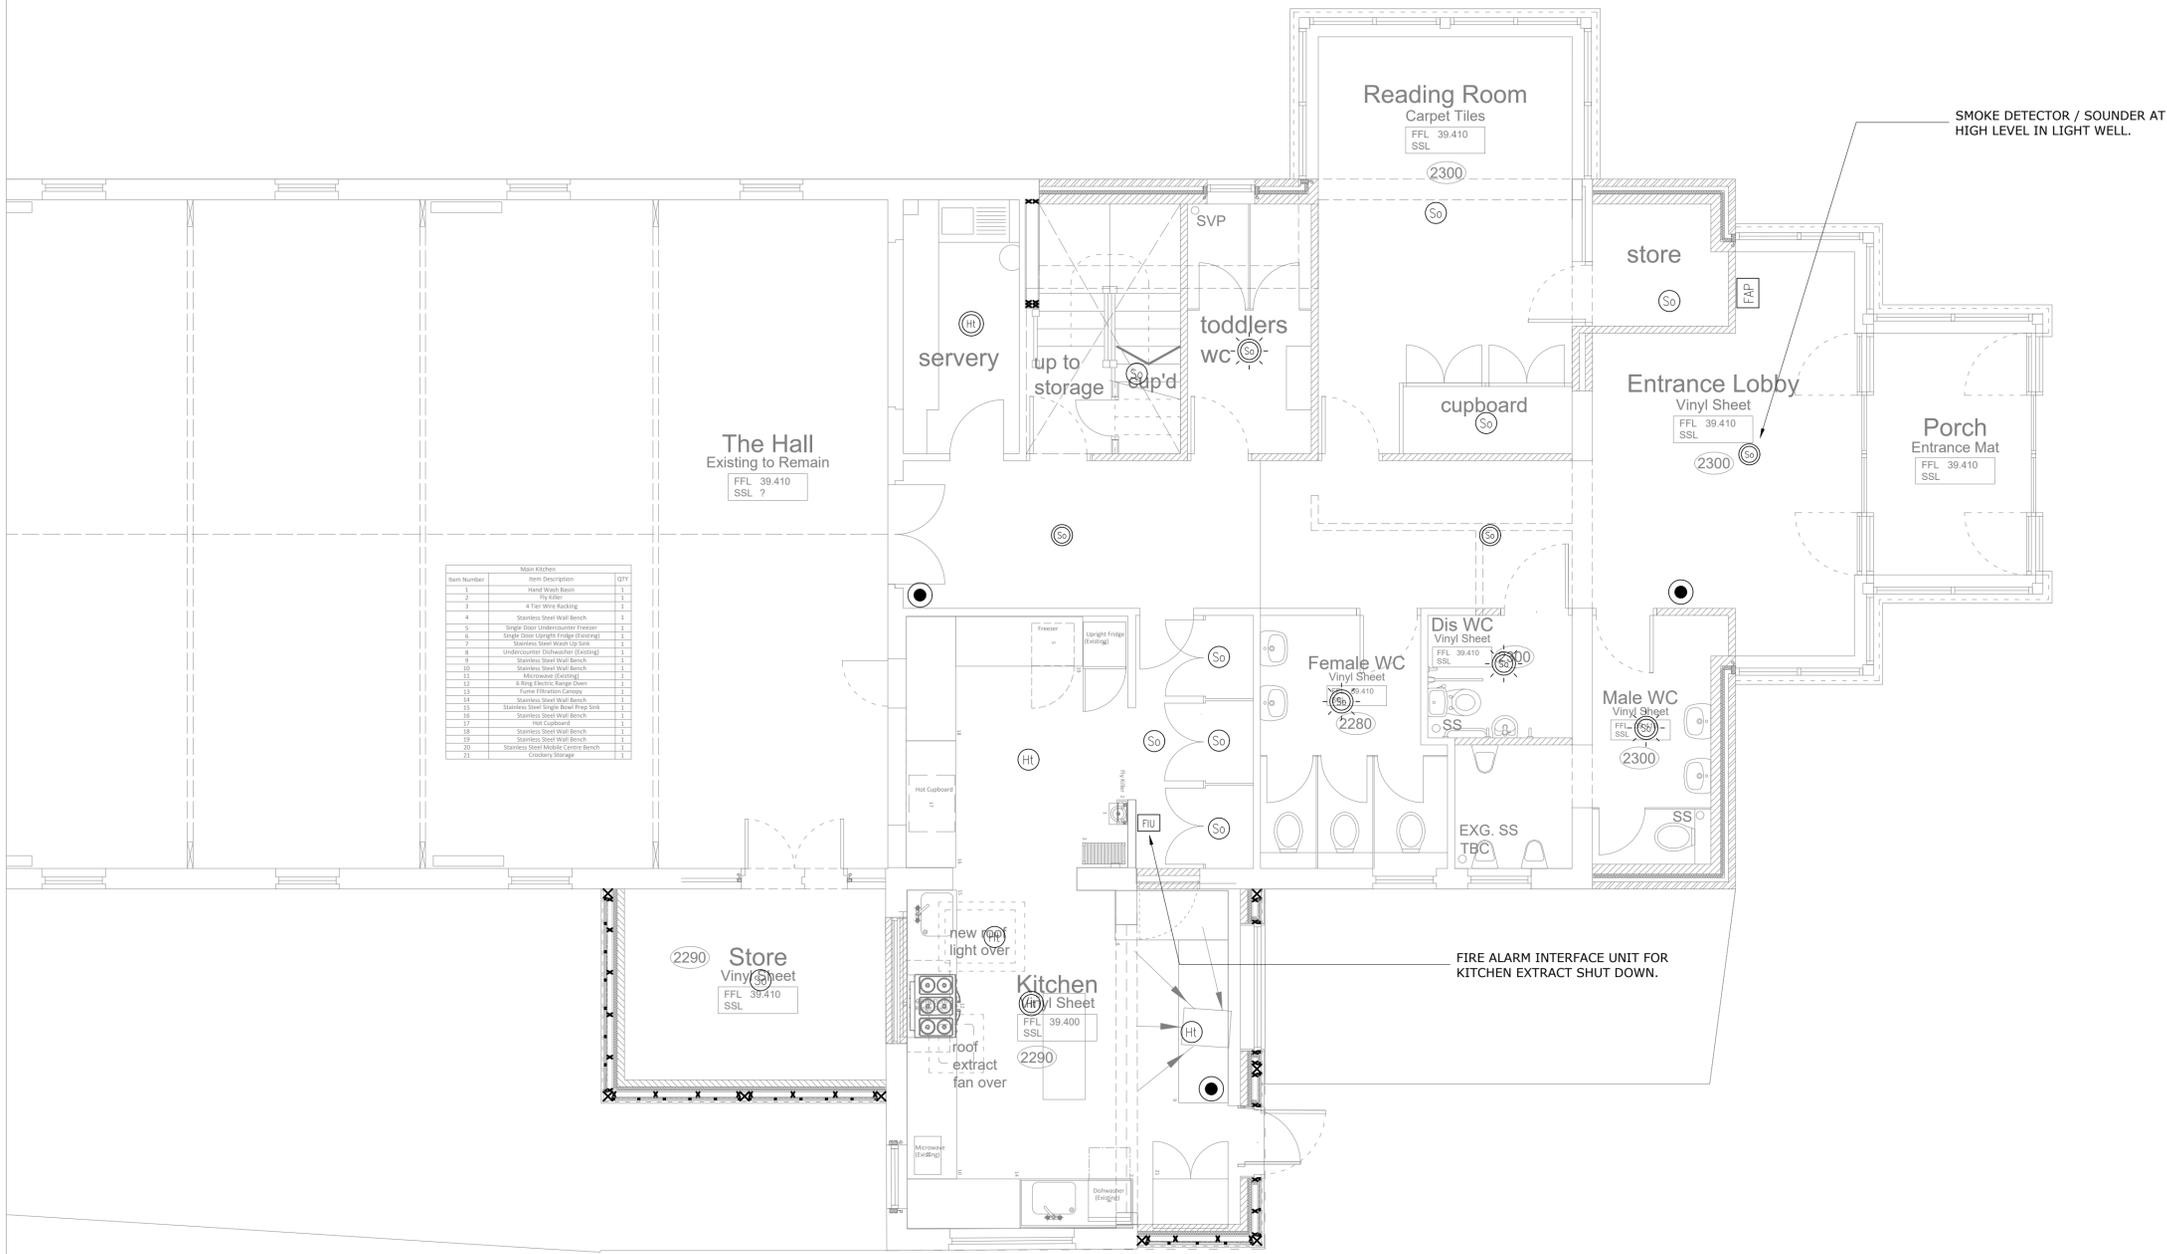

Main Kitchen

Item Number	Item Description	QTY
1	Hand Wash Basin	1
2	Tap Mixer	1
3	4 Tier Wire Racking	1
4	Stainless Steel Wall Bench	1
5	Single Door Undercounter Fridge	1
6	Single Door Upright Fridge (2 doors)	1
7	Stainless Steel Wash Up Sink	1
8	Undercounter Dishwasher (Exiting)	1
9	Stainless Steel Wall Bench	1
10	Stainless Steel Wall Bench	1
11	Microoven (Exiting)	1
12	6 Ring Electric Range Oven	1
13	Pusher Hotplate Canopy	1
14	Stainless Steel Wall Bench	1
15	Stainless Steel Single Hand Prep Sink	1
16	Stainless Steel Wall Bench	1
17	Hot Cupboard	1
18	Stainless Steel Wall Bench	1
19	Stainless Steel Wall Bench	1
20	Stainless Steel Mobile Carton Bench	1
21	Cookery Storage	1