

Project name  
**Peregrini Lindisfame Repair Works**  
**Reading Room**


Date February 2018 Drawn by JC Scale 1:50@A1

Job no 1183 Drawing no TE1 Rev


For  
**Peregrini Lindisfame**

Drawing title  
**Tender - Existing**  
**Plans, Elevations & Section AA**

Discrepancies, ambiguities and/or omissions between this drawing and information given elsewhere must be reported to the architect before proceeding.  
 This drawing is copyright.  
 Dimensions must be checked on site.  
 Do not scale off dimensions from this drawing.

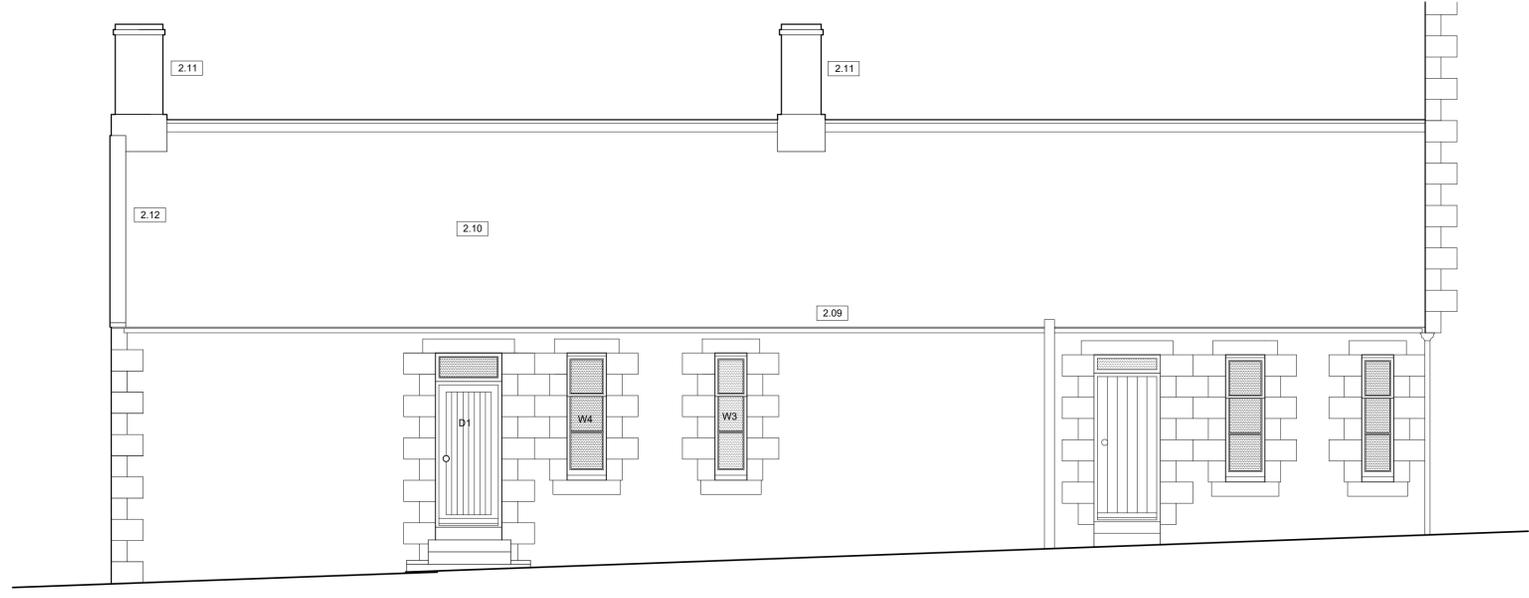


NORTH ELEVATION

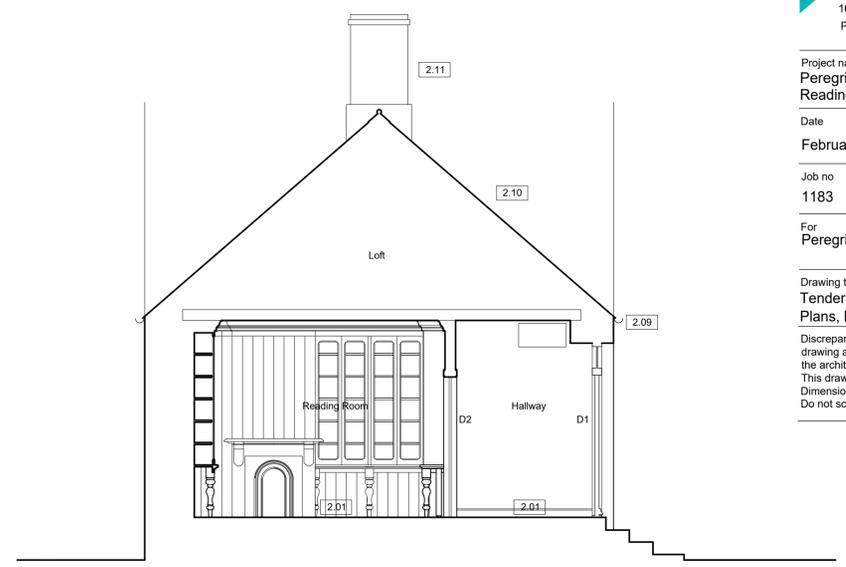

SECTION AA

**Key (Mechanical and Electrical):**  
 Those fittings shown in green on drawing are redundant and to be removed

-  Ceiling-mounted pendant light fitting
-  Wall-mounted external light
-  Single light switch
-  Double 13A switched socket
-  Switched fused spur
-  Electric radiator
-  Electricity distribution board
-  Telephone socket

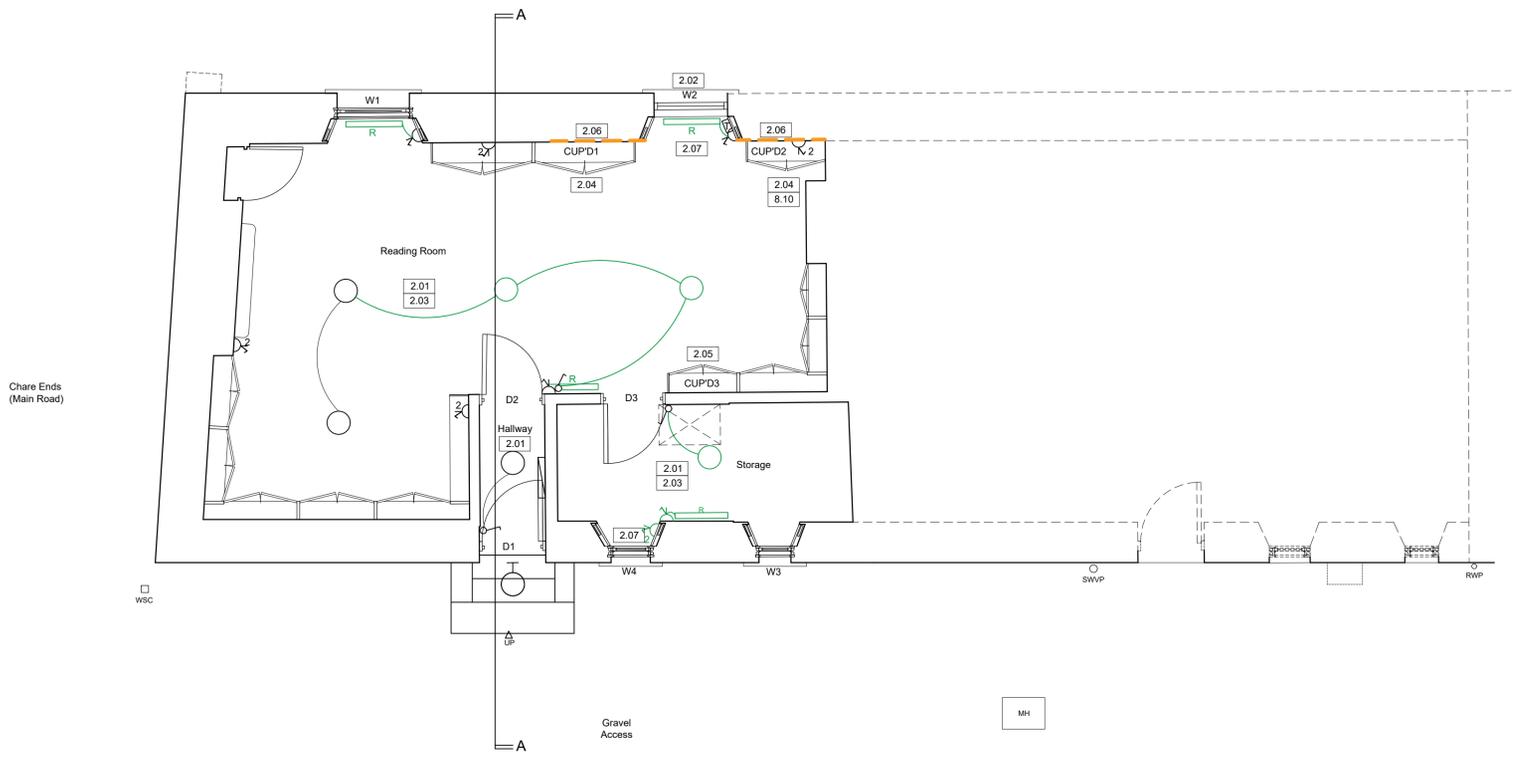

Chare Ends (Main Road)

GROUND FLOOR PLAN

