

THIS DRAWING IS INDICATIVE AND REPRESENTS ONLY THE DESIGN INTENT, THE CONTRACTOR MUST PRODUCE FULLY CO-ORDINATED WORKING / INSTALLATION DRAWINGS AS REFERRED TO IN THE CONTRACT DOCUMENTATION

NOTES


- DIMENSIONS ARE IN MILLIMETERS UNLESS OTHERWISE STATED.
- THE DRAWING SHALL BE READ IN CONJUNCTION WITH ALL OTHER MEP SERVICES DRAWINGS & SPECIFICATIONS.
- THE CONTRACTOR IS OBLIGED TO BE FULLY AWARE OF ALL EXISTING SERVICES IN ASSOCIATED AREA OF WORKS, THAT MAY REQUIRE STRIP OUT OR RE-ROUTING.
- REFER TO ARCHITECTS DRAWINGS FOR DETAILS OF ENCLOSURE AND LOUVRE ARRANGEMENT.
- CONTRACTOR TO ALLOW FOR ALL WORKS ASSOCIATED WITH THE DEMOLITION OF THE EXISTING ENCLOSURE.

ELECTRICAL LEGEND

- 26W LINEAR SURFACE MOUNTED IP65 DUST & WATER RESISTANT PROOF AS THORN FORCE LED CAT REF:- 96628626/FLP4500 C4K
- 25W 3 HOUR INTEGRAL EMERGENCY TYPE
- CIRCULAR SURFACE MOUNTED IP65 LUMINAIRE AS THORN PIAZZA II LED CAT REF:- 96666263
- 3 HOUR INTEGRAL EMERGENCY TYPE
- COMBINE PHOTOCELL / PIR IP65 RATED
- SWITCH
- 2 SWITCH
- KEY SWITCH
- SWITCH SOCKET OUTLET
- FUSED CONNECTION UNIT
- ISOLATOR
- FIRE ALARM BREAK GLASS
- FIRE ALARM COMBINE SOUNDER, DETECTOR & FLASHING BEACON
- FIRE ALARM INTERFACE UNIT



EXISTING ELECTRICAL SERVICES TO BE RETAINED WHERE LIVE & OPERATIONAL & ISOLATED, DISCONNECTED & REMOVED WHERE REDUNDANT (SEE IMAGE ABOVE)

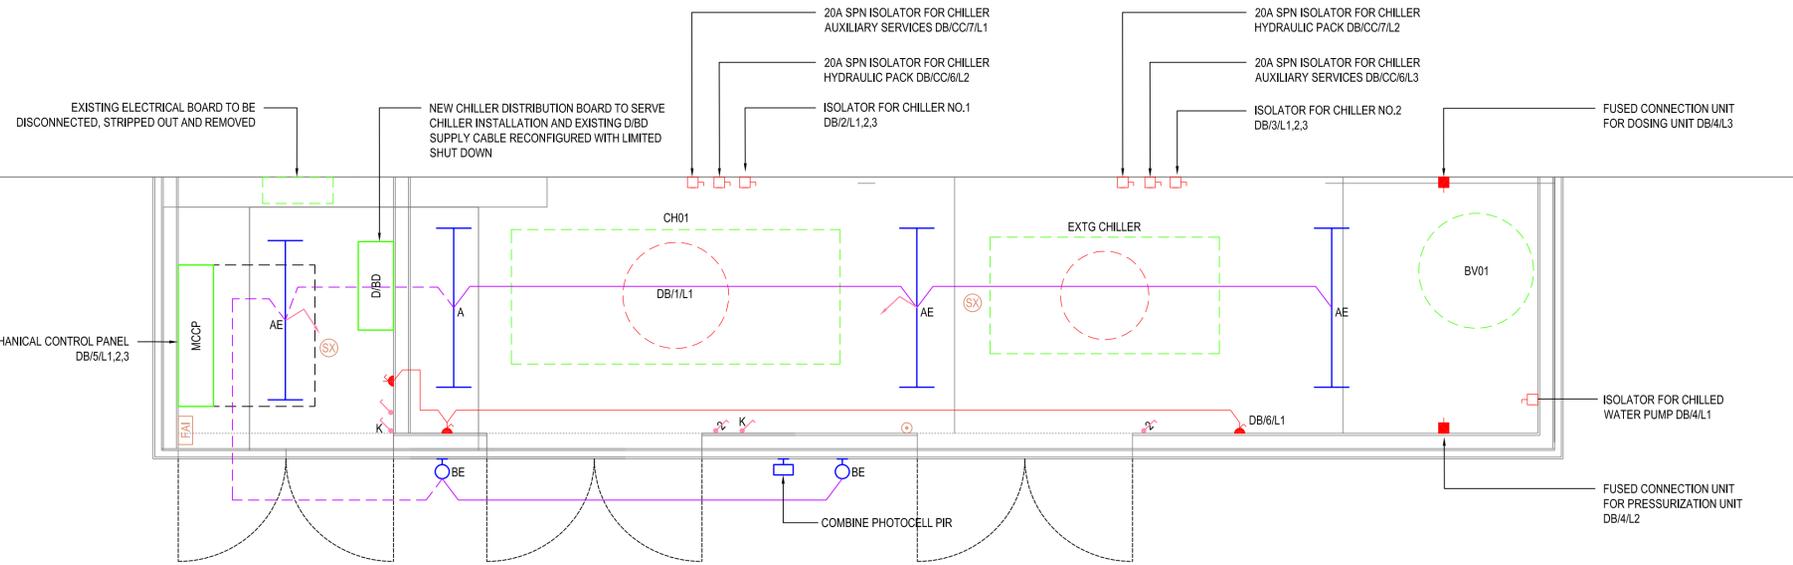

EXTERNAL PLANT ENCLOSURE LAYOUT
ELECTRICAL SERVICES LAYOUT
SCALE 1:20

T01	TENDER ISSUE	TD	AJ	CM	12.07.18
REV	DESCRIPTION	BY	CHK	APP	DATE

Project Status: **TENDER**

HARLEY HADDOW CONSULTING ENGINEERS
 Vox Studios
 1-45 Durham Street, Vauxhall
 London, SE11 5JH
 T: +44 (0) 203 735 5060
 Email - london@harleyhaddow.com
 www.harleyhaddow.com
 Association of Consulting Engineers Member Firm
 Edinburgh | Glasgow | London



Project: 302807
HORNIMAN MUSEUM AQUARIUM

Drawing Title:
AQUARIUM PLANTROOM ELECTRICAL SERVICES LAYOUT

Scale @ A1 1:20	Date JULY 2018	Engineer AJ
Drawing No. 2807-HAH-00-XX-DR-E-60-0100	Revision T01	