


**NOTES**

Light fittings shown in existing positions for reference.  
 Ceiling grid is indicative.  
 Existing position of services indicated, will need to be relocated / lowered to facilitate the new suspended ceiling.  
 Position of new power supplies and thermostat for heating subject to confirmation by mechanical contractor.

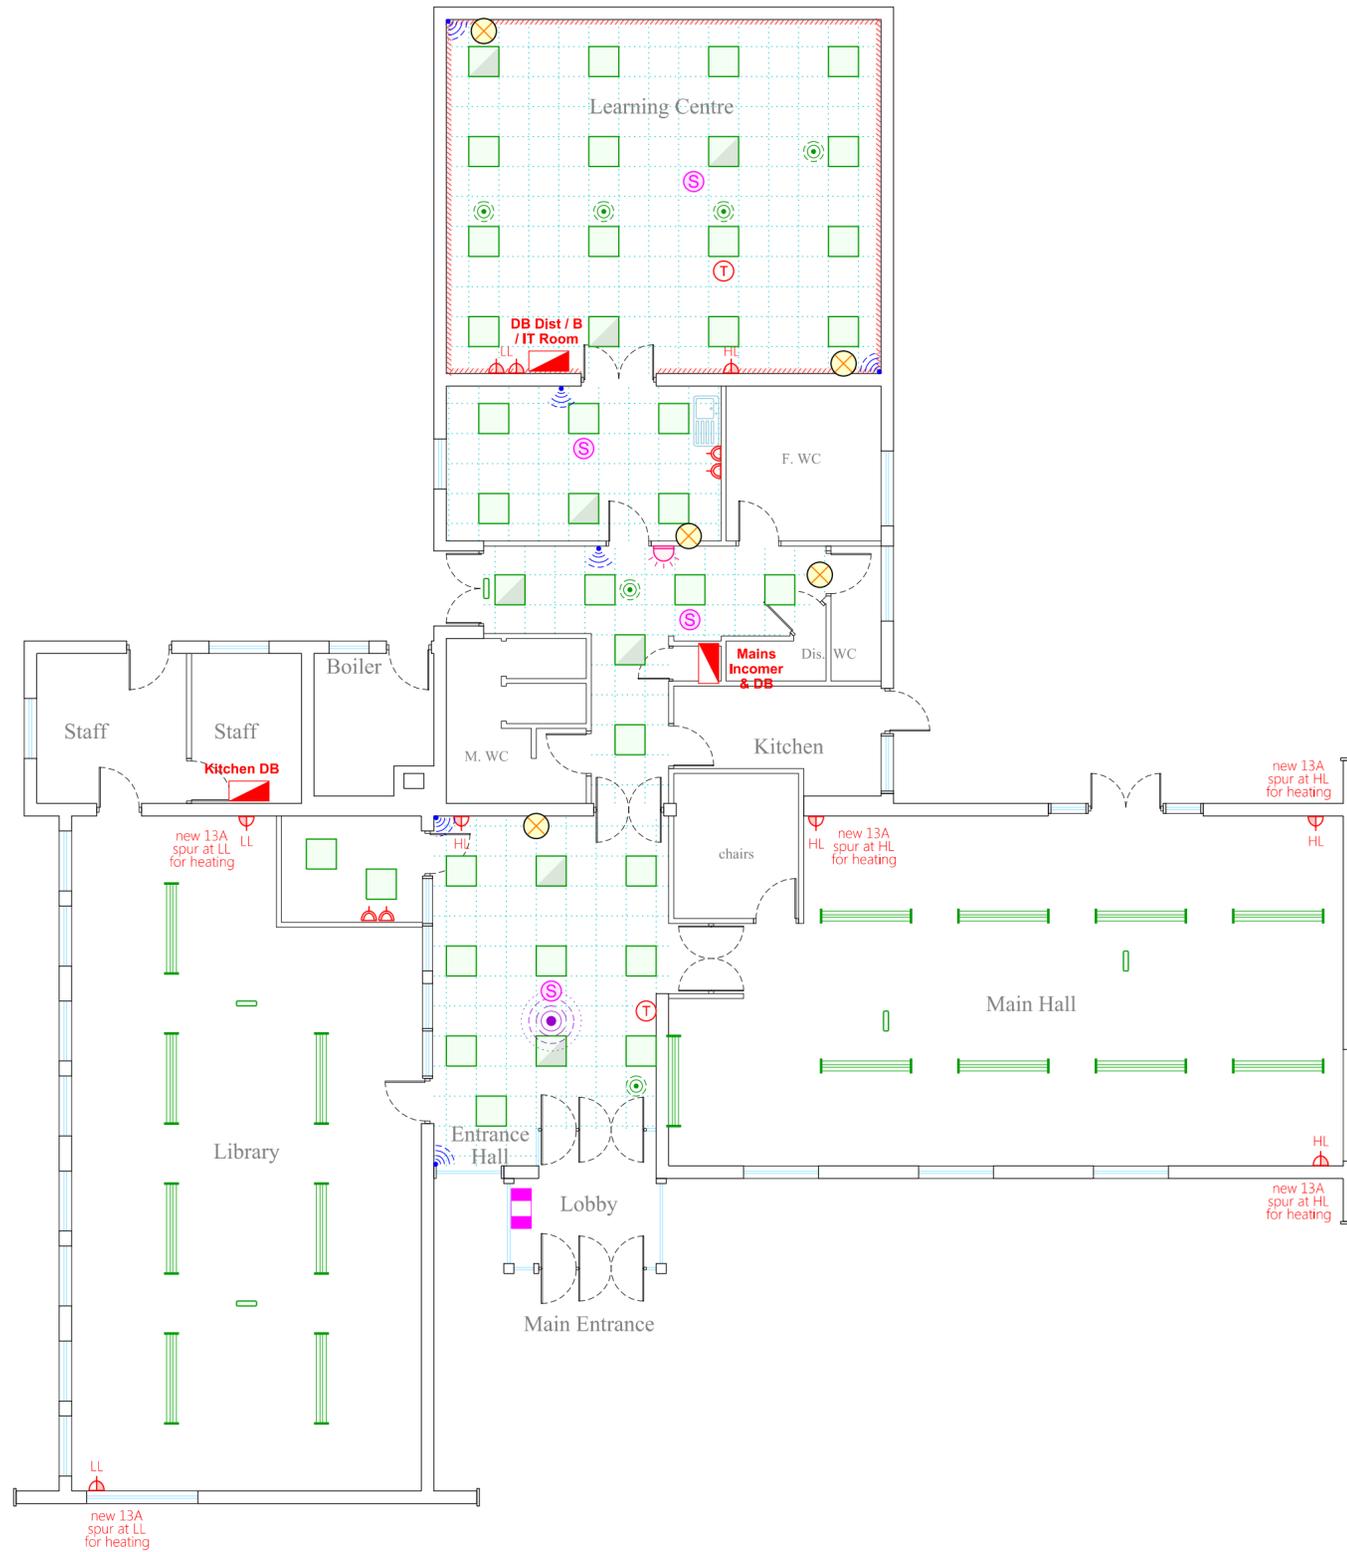

**LEGEND**

**POWER and DATA**

- Distribution Board
- PVCu dado trunking
- 13A twin switched socket switched fused connection unit  
LL = low level HL = high level
- WIFI Router

**LIGHTING**

- recessed modular luminaire standard / emergency fitting
- linear fitting, twin lamp
- emergency bulkhead, ceiling mounted
- PIR presence detector

**FIRE ALARM and SECURITY**

- Fire Alarm Control Panel
- smoke detector
- motion detector
- CCTV, dome camera
- alert light for disabled toilet alarm

Building plan supplied by:

**Swindon Borough Council**  
 Technical Services Group, Property Services,  
 Civic Offices, Euclid Street, Swindon, SN1 2JH

**NB : Building plan manually transcribed from paper print, all measurements are approximate.**

Rev.	Date	Details	By
0	05/04/2018	blank for markup	A.T.
0a	17/04/2018	F. WC altered, doors added	C.C.
1	27/04/2018	building size adjusted, proposed mechanical layout	C.C.
1a	03/05/2018	final revisions for tender issue	C.C.

Rev0 blank : Rev1 for comment : Rev2 for construction : Rev3 as fitted

Client  
**Central Swindon North Parish Council**  
 Pinetrees Community Centre, The Circle, Pinehurst, Swindon, SN2 1QR  
 Tel: 01793 466499 www.centalswindonnorth-pc.gov.uk

Project  
**John Moulton Hall**  
 Penhill Drive, Swindon, SN2 5DU  
 Building Condition Report 2018

Drawing Title  
*Proposed Works*  
**ELECTRICAL SERVICES**  
*for tender*

Project No.	Drawing No.	Revision
9097	E01	1a

Scale	Drawn	Checked	Date
1:100 @ A2	A.T.	C.C.	03/05/2018

Scale 1:100 at A2 (1:200 at A4)



Scale applies to buildings only. All installation positioning is arbitrary.