

9850



- For tendering purposes only.
- Do not use for fabrication.
- It is the contractors responsibility to check all information contained on this drawing.
- This Drawing is the copyright of the Forestry Commission and shall not be used for any purpose, or copied, or communicated to any other party without the written consent of the Forestry Commission.

Client:
West England Forest District

Project:
Cockercombe Office

Grid ref: XXXX

Title:
Existing Floor plan

Date: July17
Drawn: B.W. Kedward


Scale:
1:50 @ A3
Dimensions in millimetres

Drawing No.
17/Quant01/001

14260



Forestry Commission
England
Bank House
Bank Street, Coleford
Gloucestershire
GL16 8BA

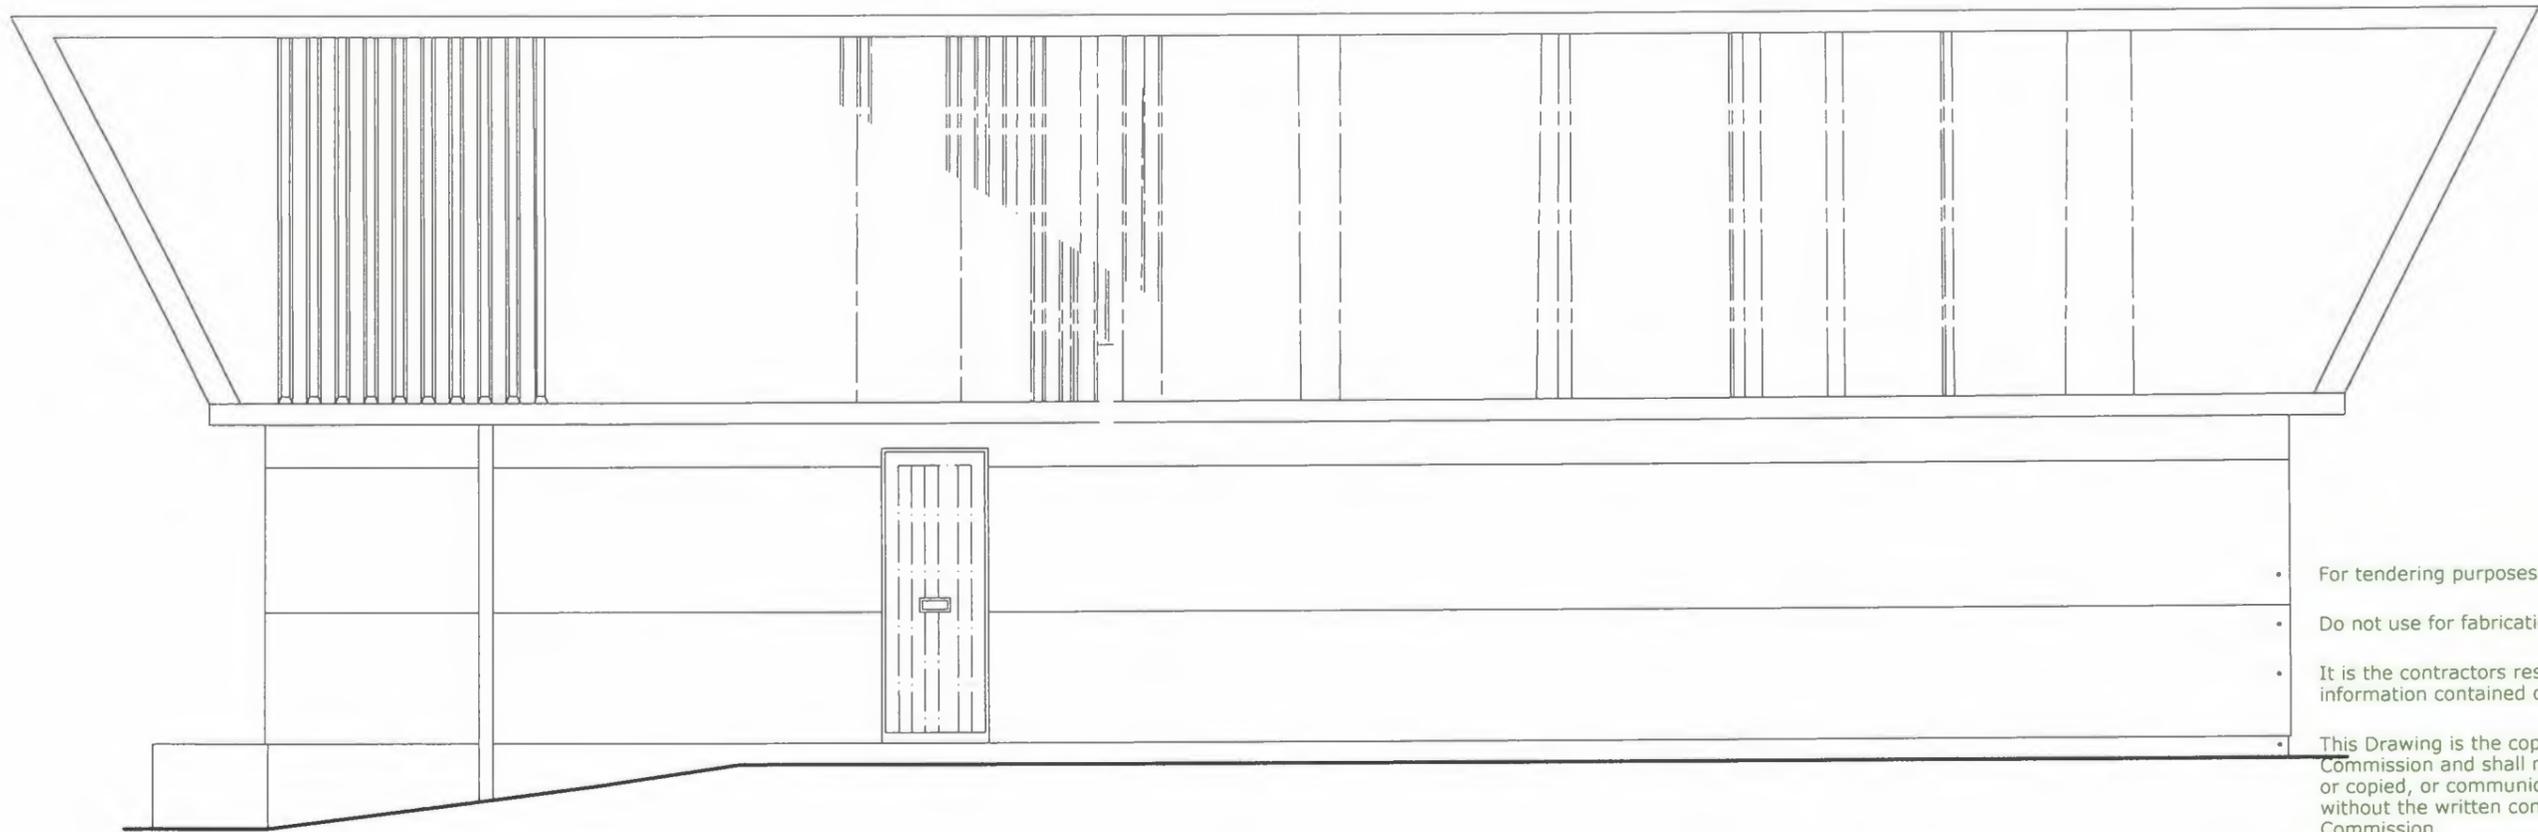

- For tendering purposes only.
- Do not use for fabrication.
- It is the contractors responsibility to check all information contained on this drawing.
- This Drawing is the copyright of the Forestry Commission and shall not be used for any purpose, or copied, or communicated to any other party without the written consent of the Forestry Commission.

Client:

West England Forest District

Project:

Cockercombe office refurb

Grid ref:

Title:

Existing N & E Elevations

Date:

Sept 17

Drawn:


B.W. Kedward

Scale:


1:50 @ A3
Dimensions in millimetres

Drawing No.

17/Quat01/002

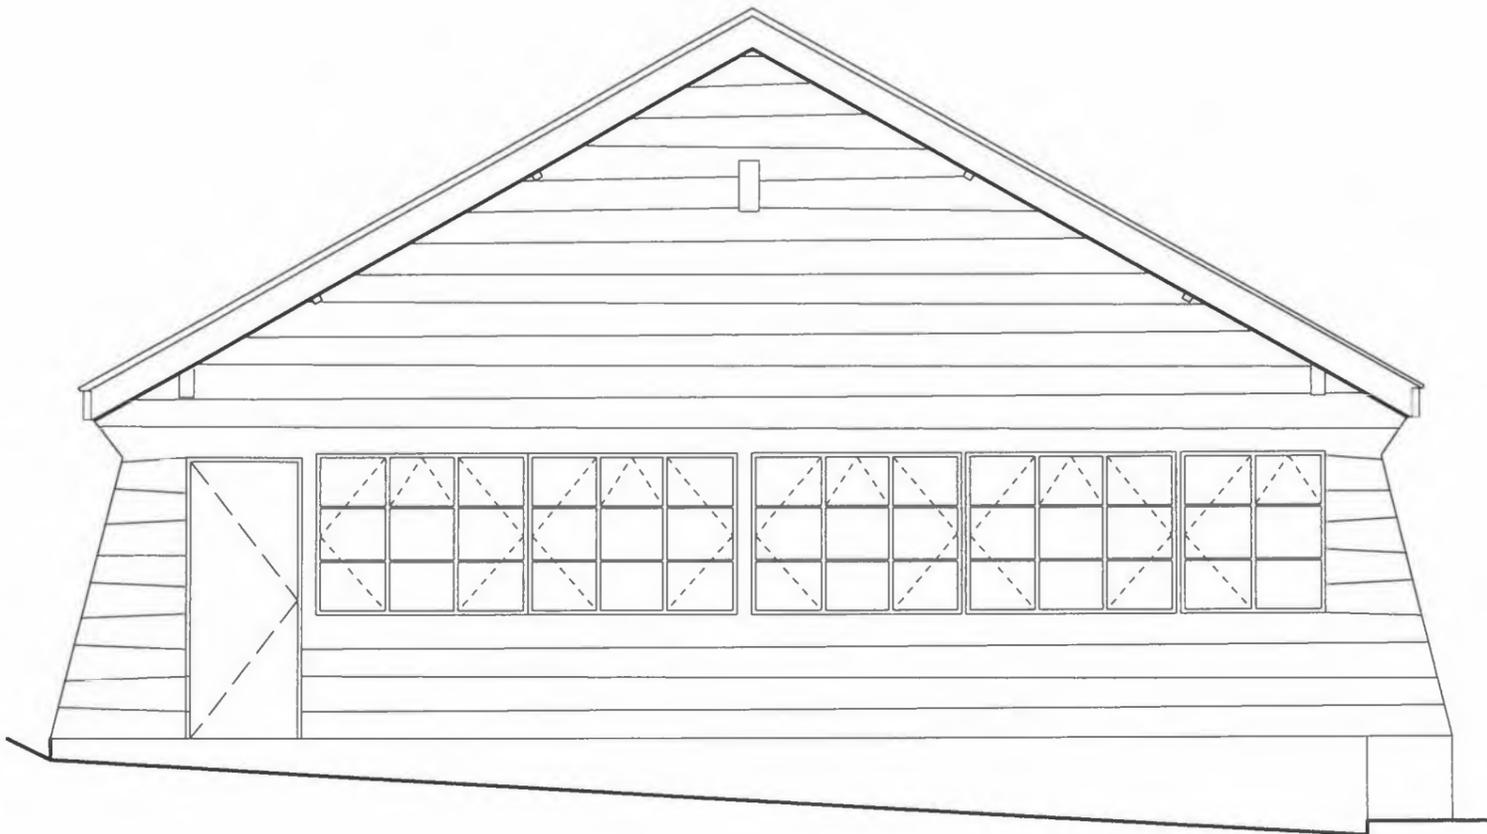

Forestry Commission
England
Bank House
Bank Street, Coleford
Gloucestershire
GL16 8BA

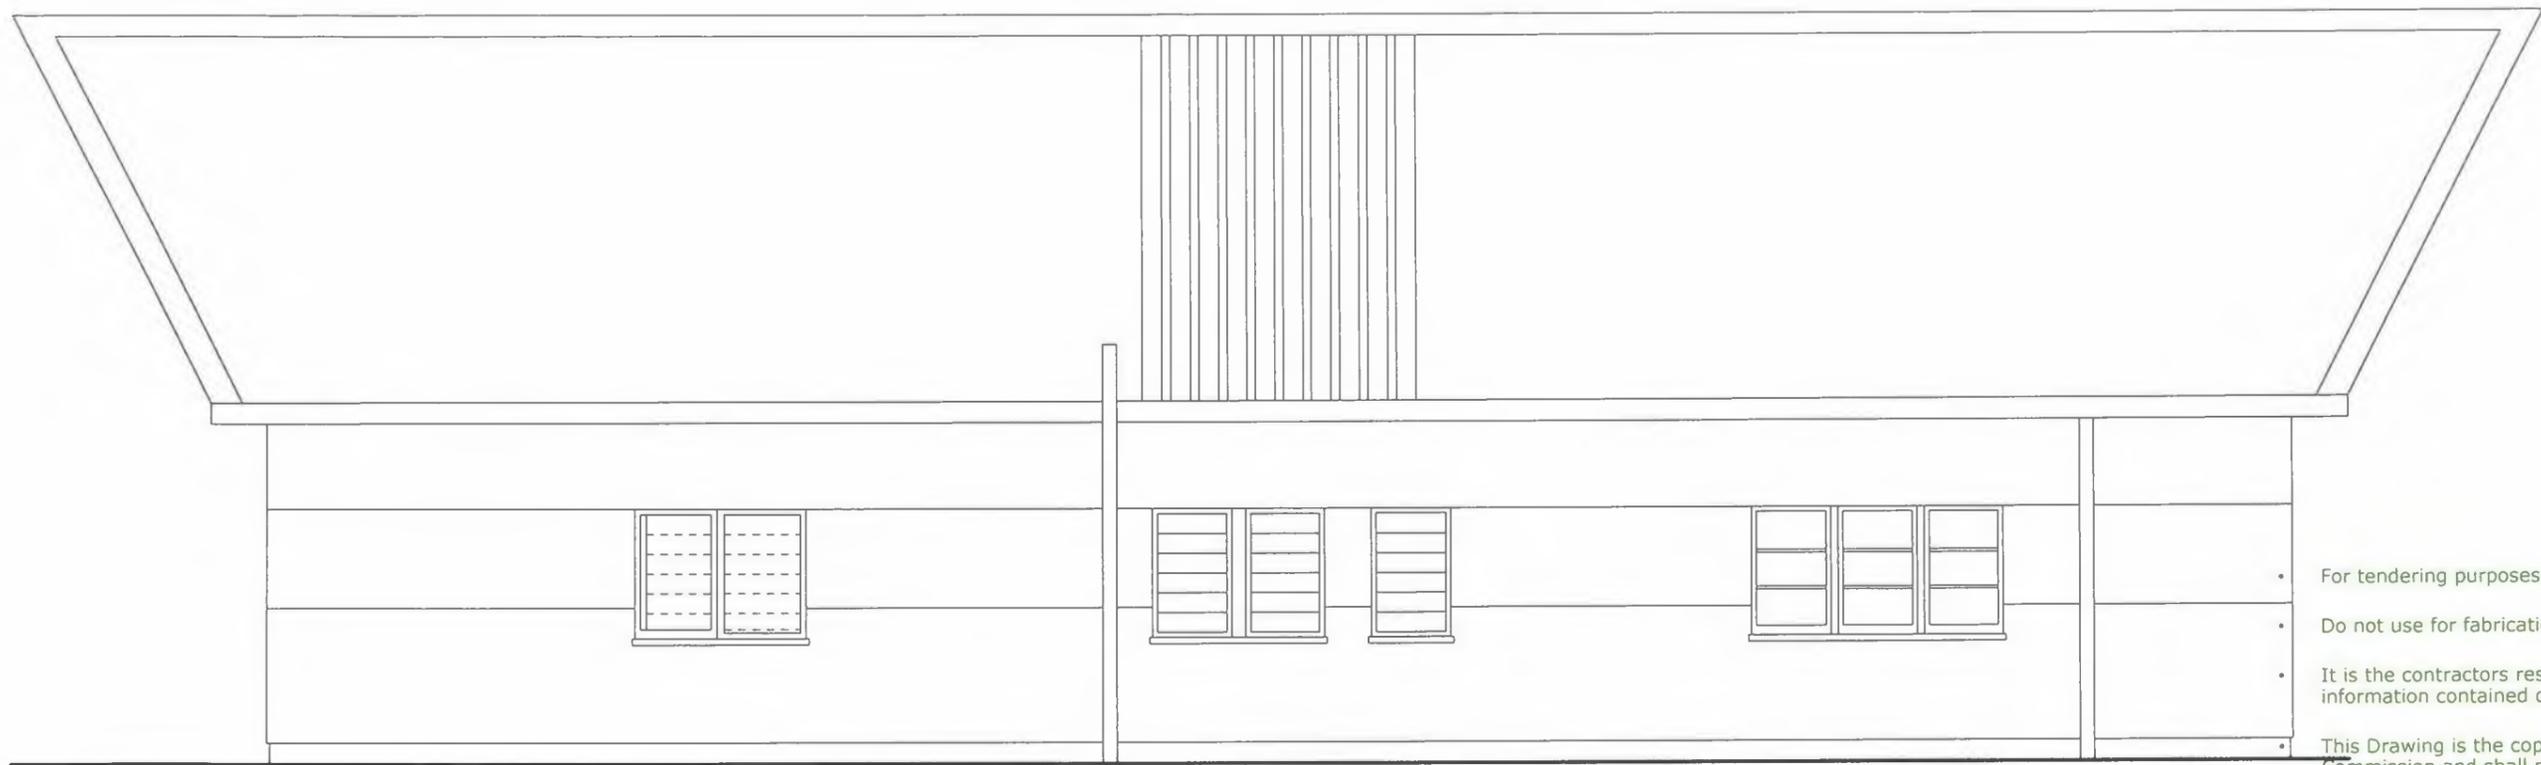

- For tendering purposes only.
- Do not use for fabrication.
- It is the contractors responsibility to check all information contained on this drawing.
- This Drawing is the copyright of the Forestry Commission and shall not be used for any purpose, or copied, or communicated to any other party without the written consent of the Forestry Commission.

Client:

West England Forest District

Project:

Cockercombe Office

Grid ref:

Title:

Existing S & W Elevation

Date:

Sept 17

Drawn:

B.W. Kedward


Scale:

1:50 @ A3


Dimensions in millimetres

Drawing No.

17/Quant01/003

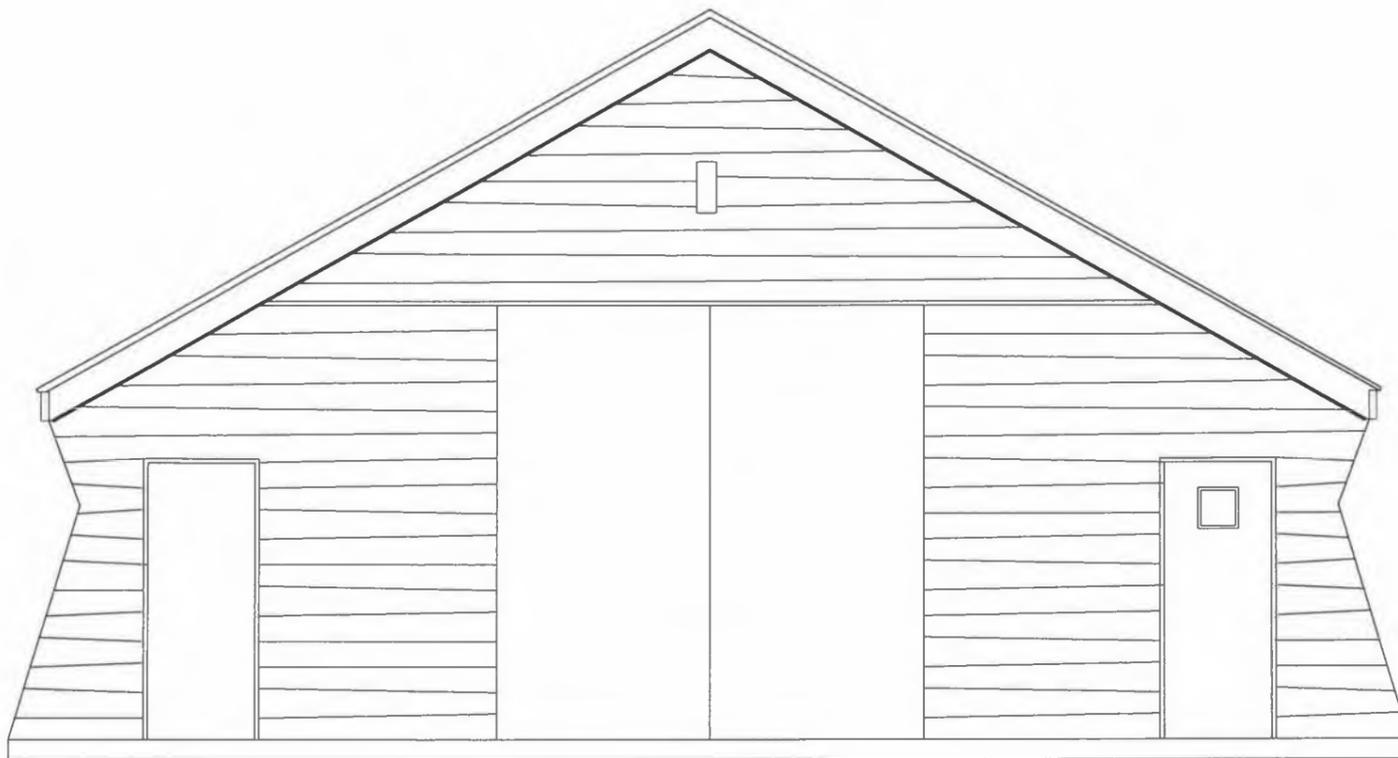

Forestry Commission
 England
 Bank House
 Bank Street, Coleford
 Gloucestershire
 GL16 8BA

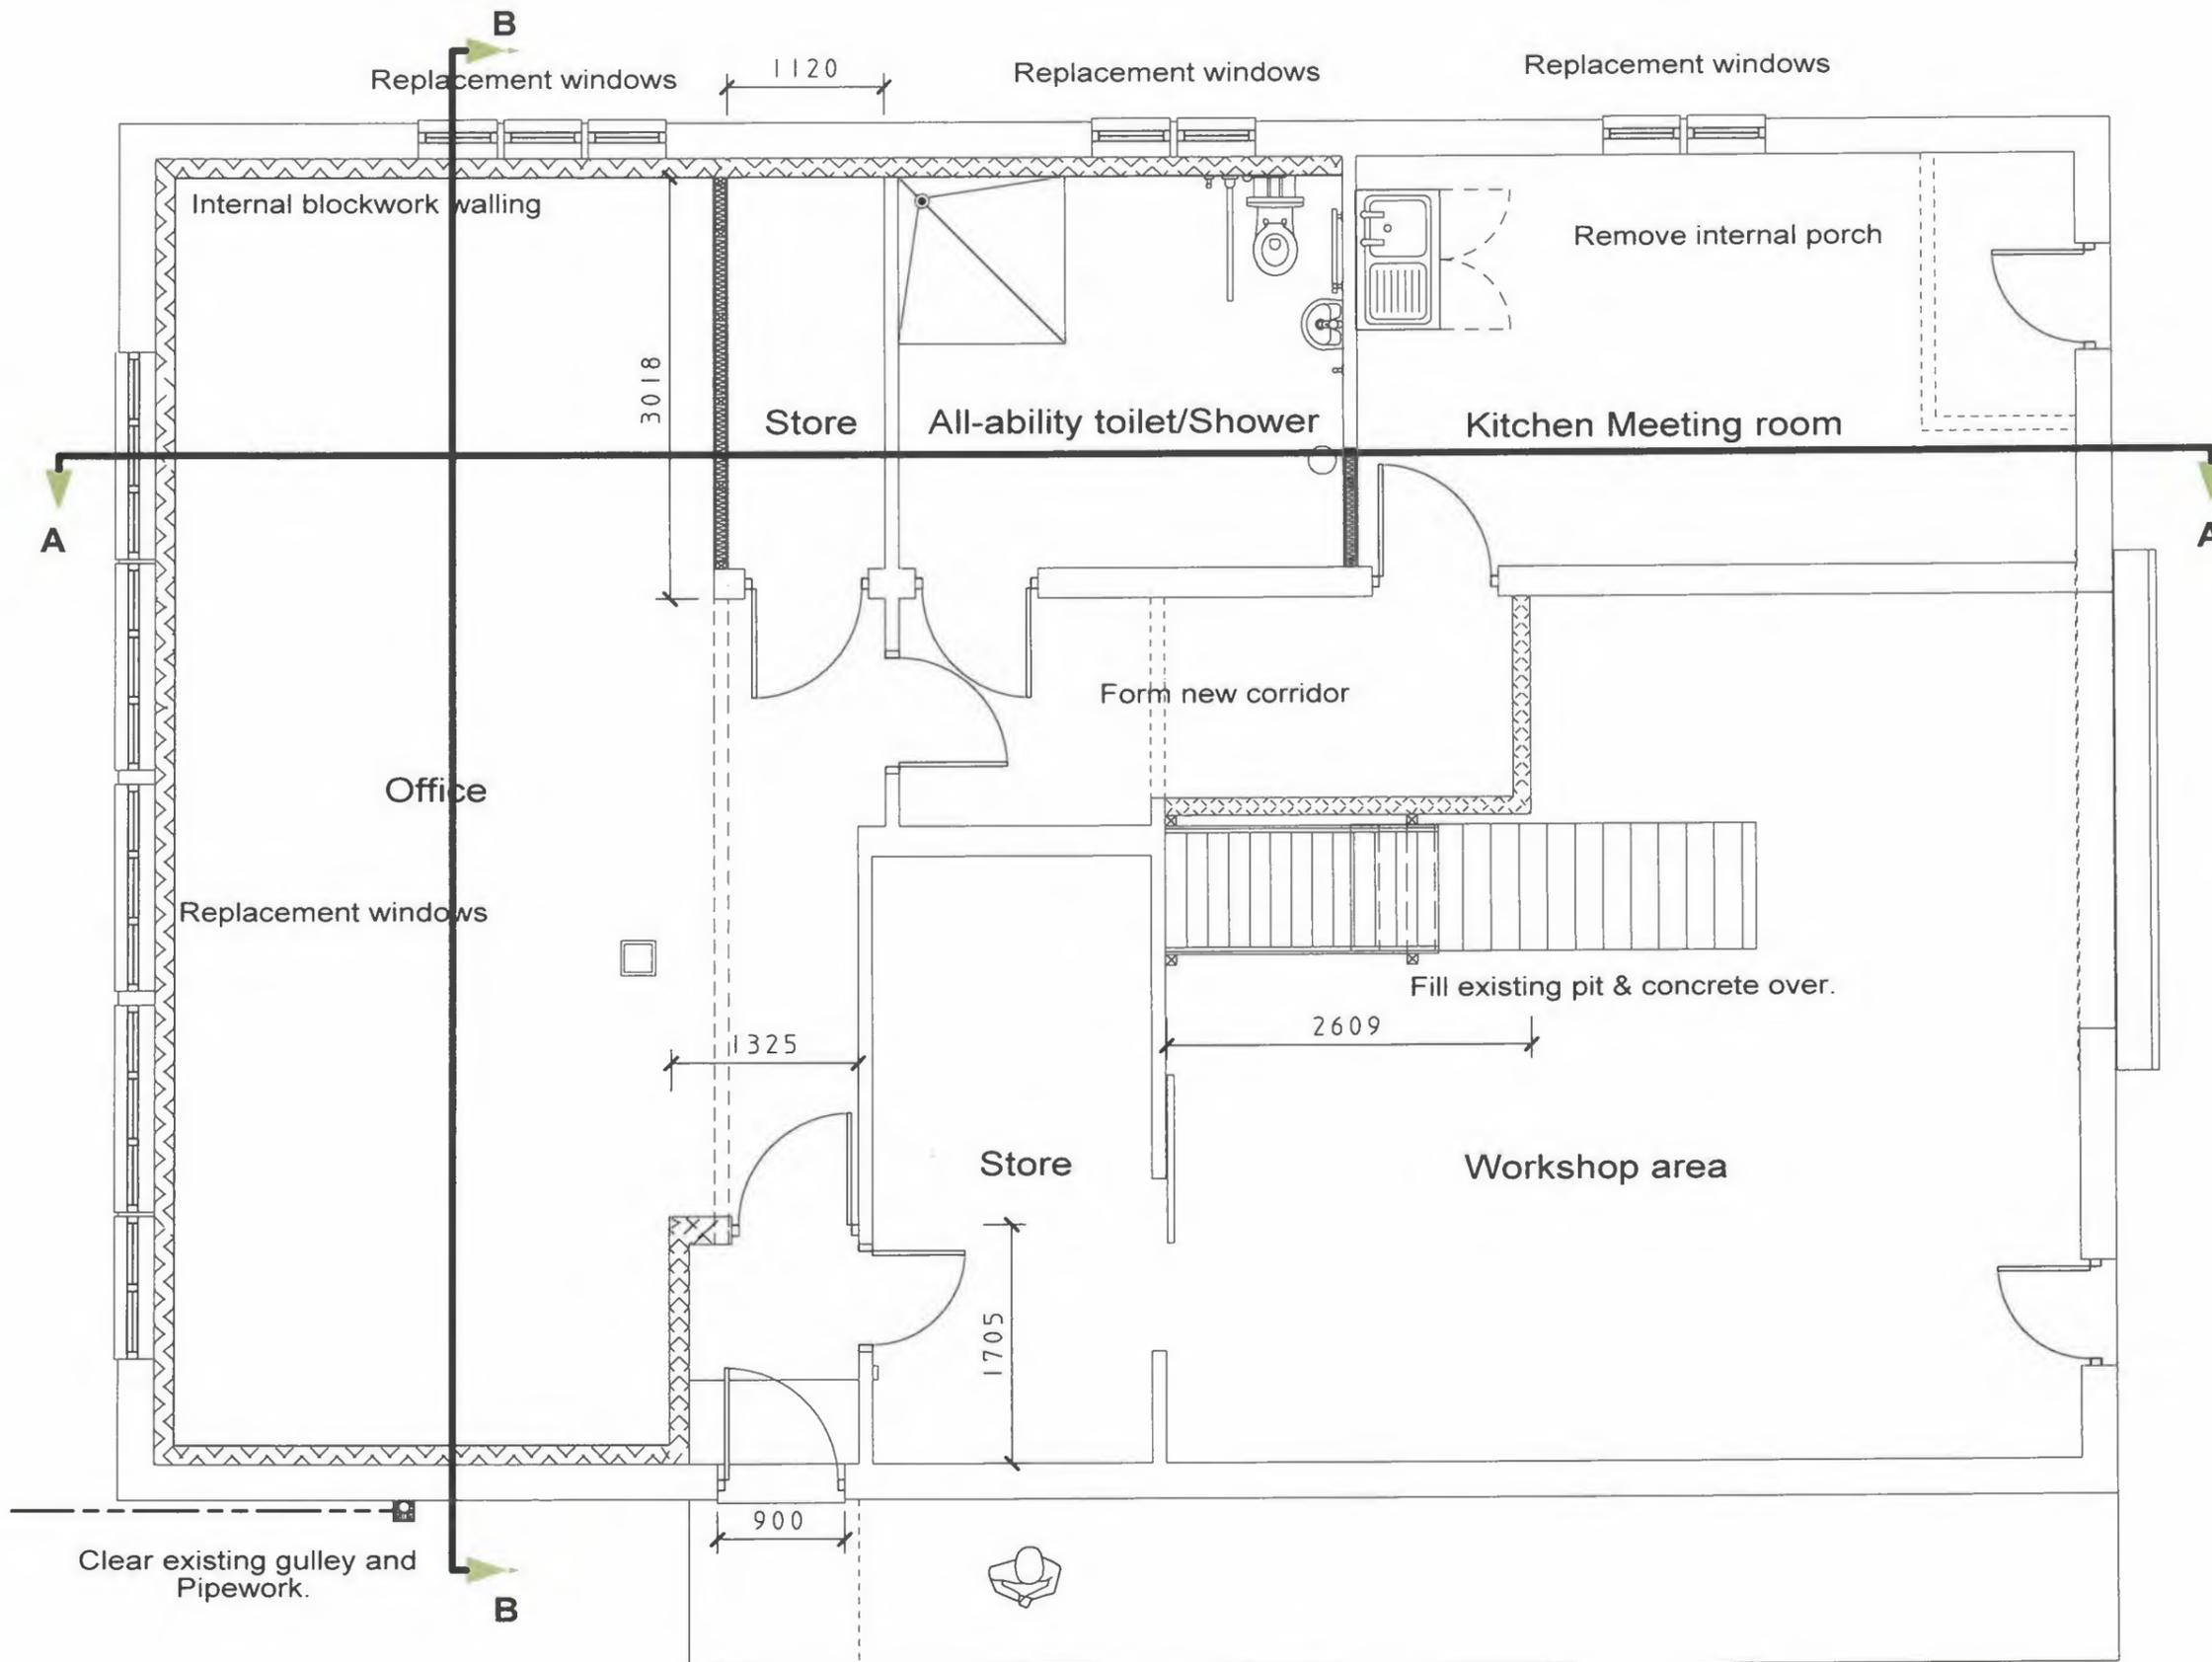

- For tendering purposes only.
- Do not use for fabrication.
- It is the contractors responsibility to check all information contained on this drawing.
- This Drawing is the copyright of the Forestry Commission and shall not be used for any purpose, or copied, or communicated to any other party without the written consent of the Forestry Commission.

Client:

West England Forest District

Project:

Cockercombe Office

Grid ref: XXXX

Title:

Proposed Floor plan

Date:

December 17

Drawn:

B.W. Kedward

Scale:

1:50 @ A3


Dimensions in millimetres

Drawing No.

17/Quant01/006 Rev1




Forestry Commission
 England
 Bank House
 Bank Street, Coleford
 Gloucestershire
 GL16 8BA

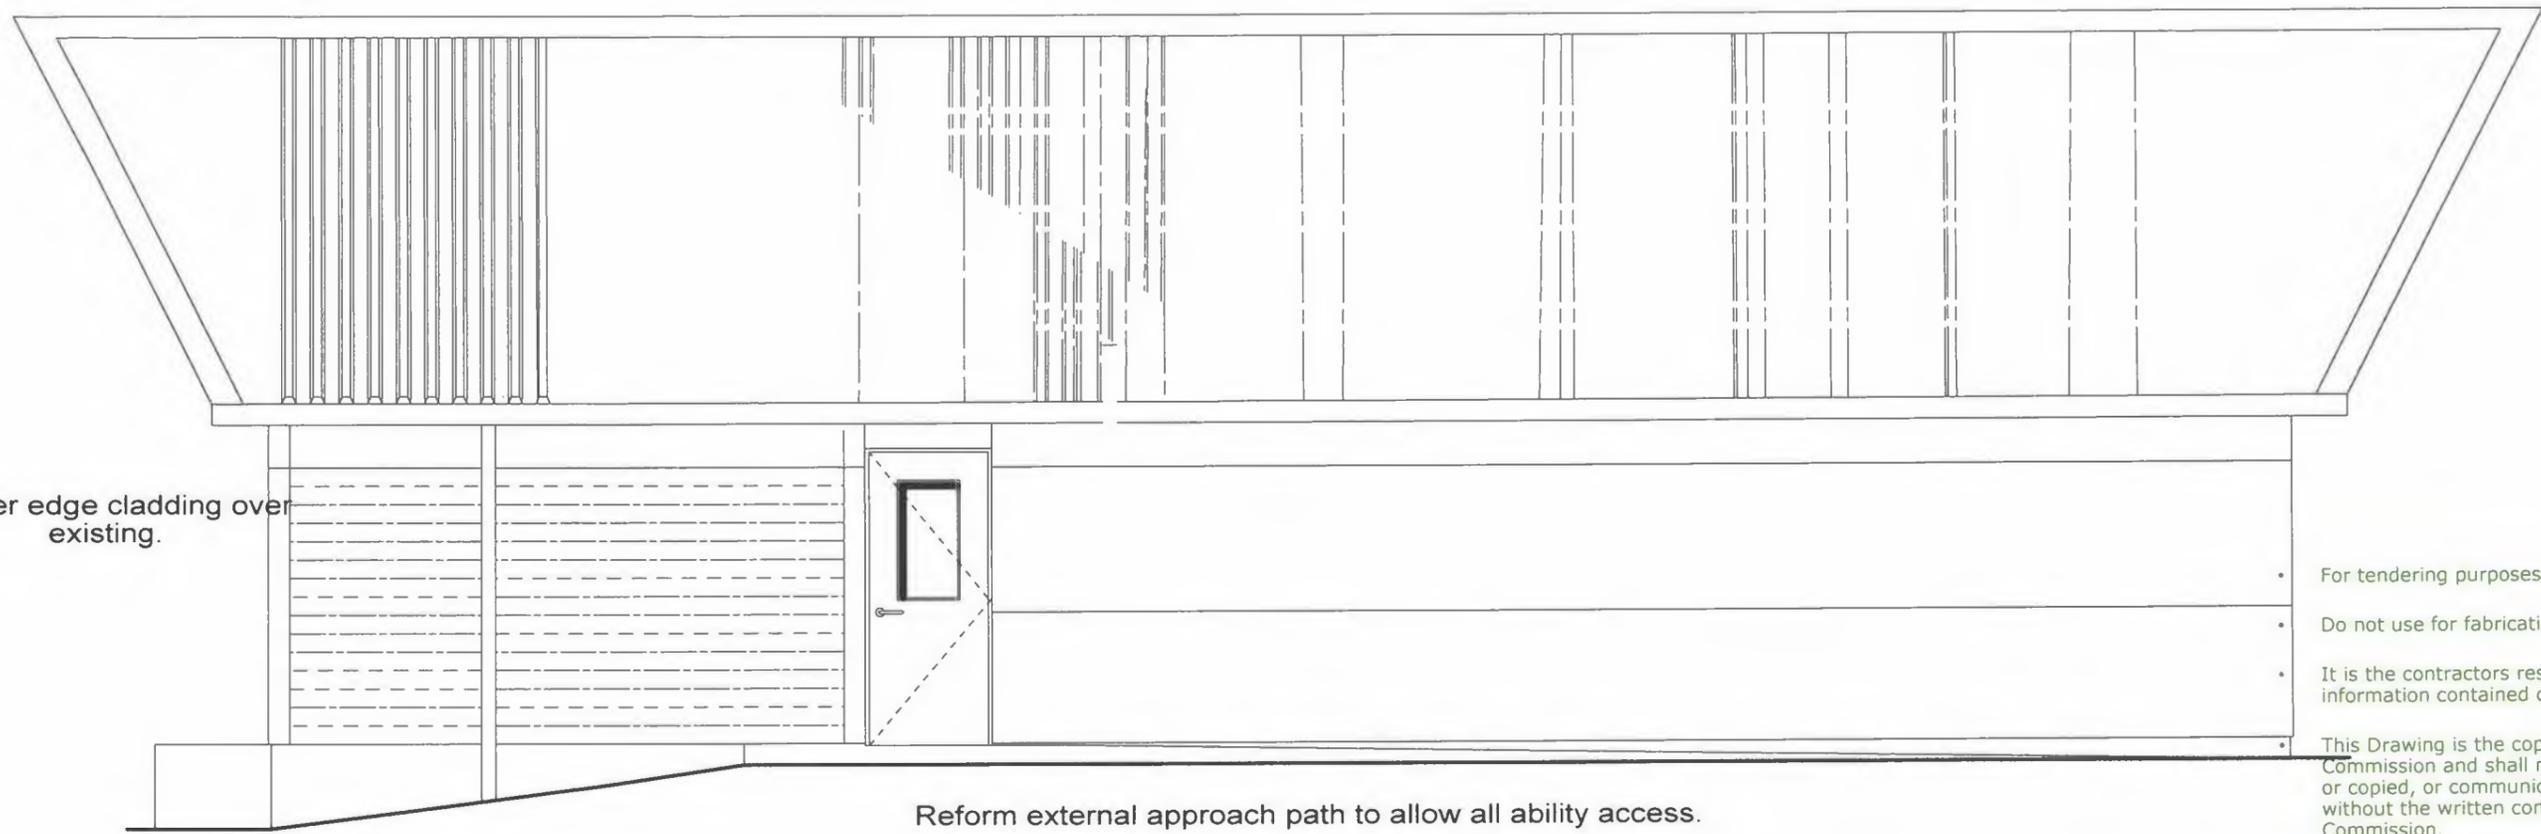

- For tendering purposes only.
- Do not use for fabrication.
- It is the contractors responsibility to check all information contained on this drawing.
- This Drawing is the copyright of the Forestry Commission and shall not be used for any purpose, or copied, or communicated to any other party without the written consent of the Forestry Commission.

North Elevation

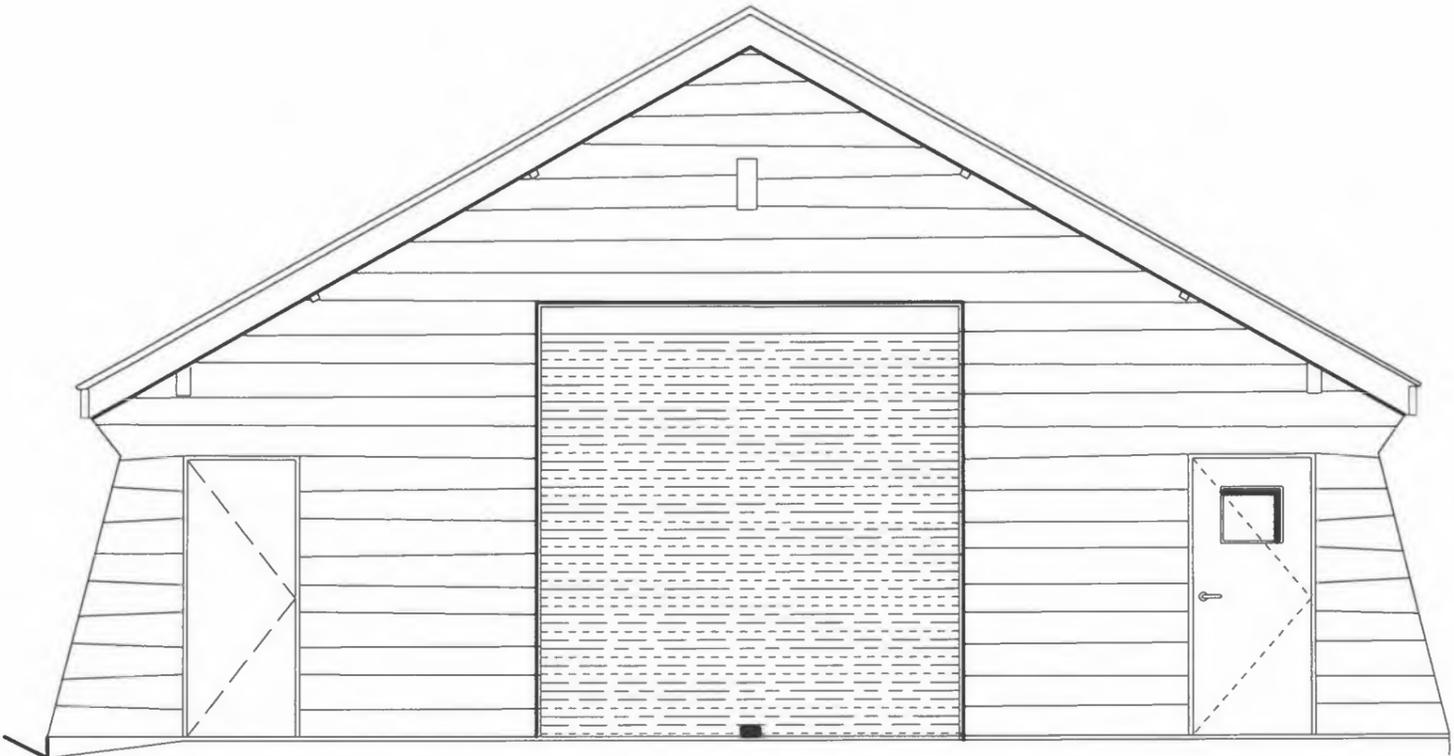

West Elevation

Replace existing industrial doors with mechanical roller shutter in Galvanised finish with floor locking.

Replace existing external doors with multi point locking security doors and frames by IG or similar approved

Client:
West England Forest District

Project:
 Cockercombe office refurb


Grid ref:

Title:
 Proposed N & W Elevations

Date: Sept 17
Drawn: B.W. Kedward

Scale:
 1:50 @ A3
 Dimensions in millimetres


Drawing No.
 17/Quat01/007

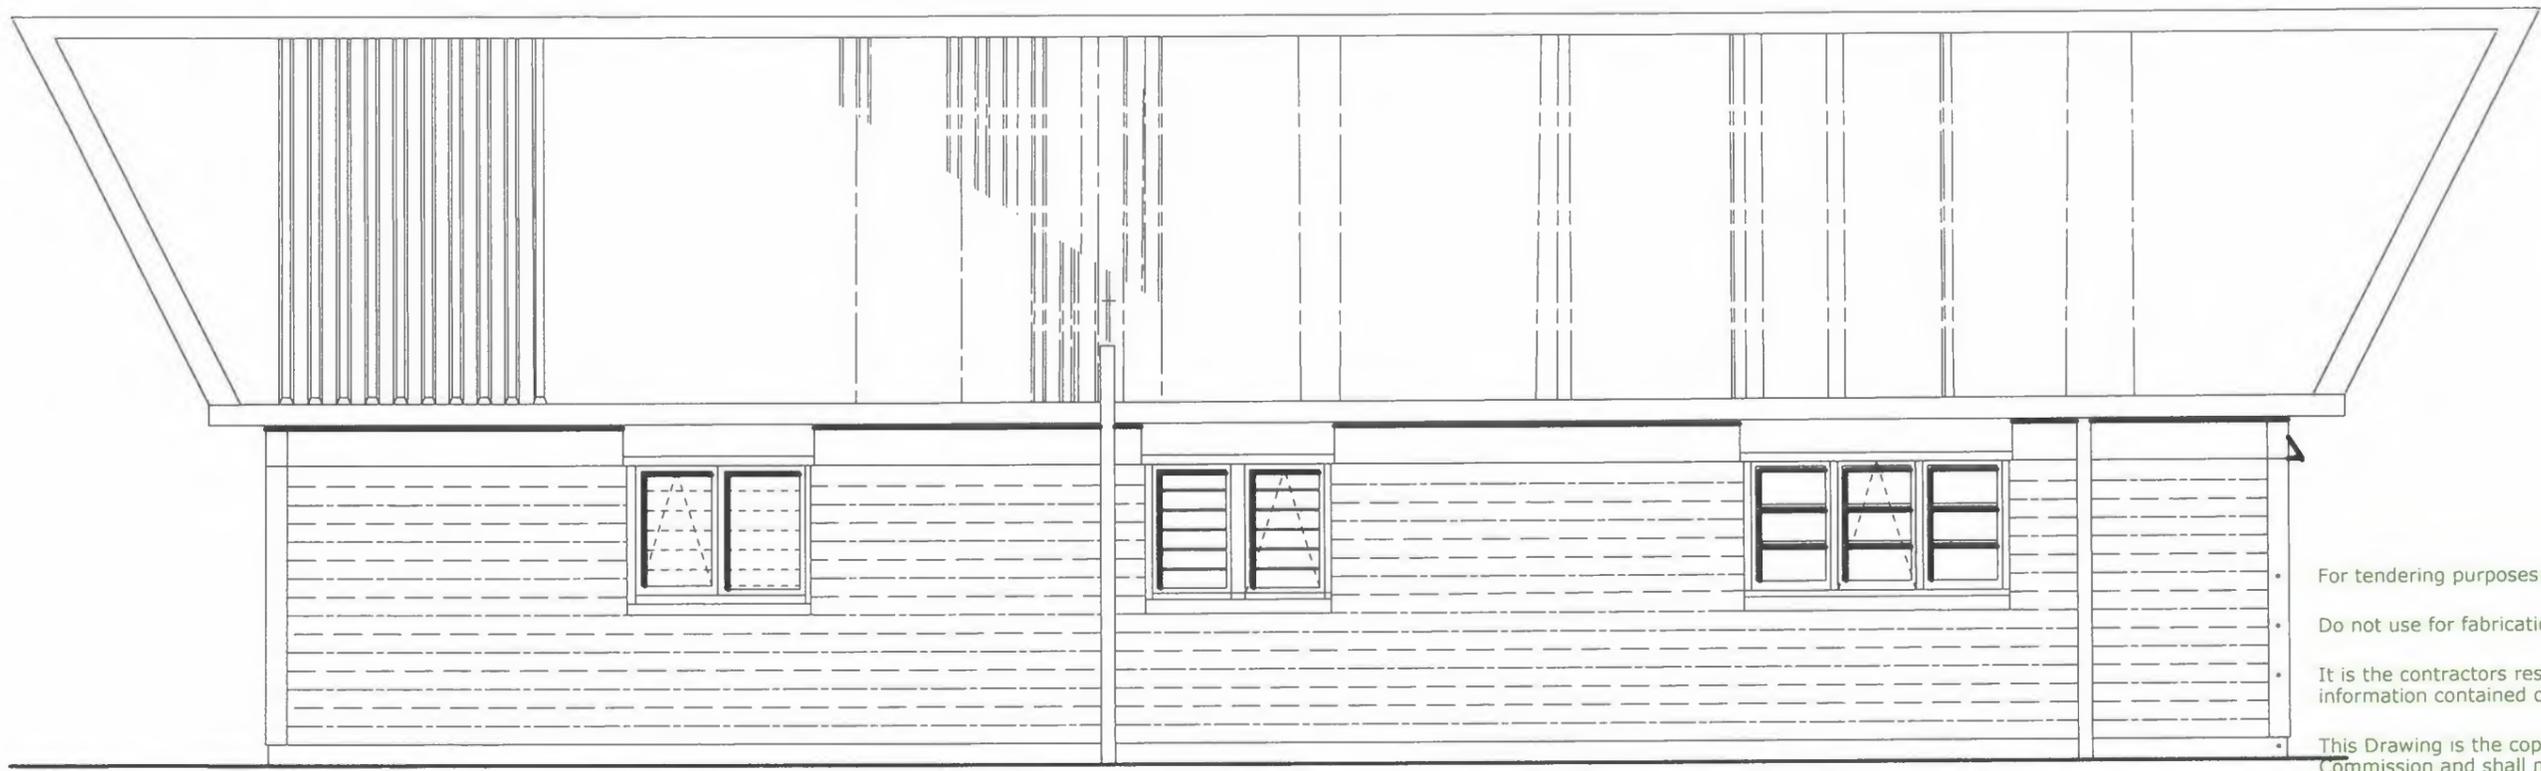

SOUTH ELEVATION

- Re Clad all of south elevation with 150 x 16mm
UK Produced Western Red Cedar feather edge boards

For tendering purposes only.
Do not use for fabrication.
It is the contractors responsibility to check all information contained on this drawing.
This Drawing is the copyright of the Forestry Commission and shall not be used for any purpose, or copied, or communicated to any other party without the written consent of the Forestry Commission.

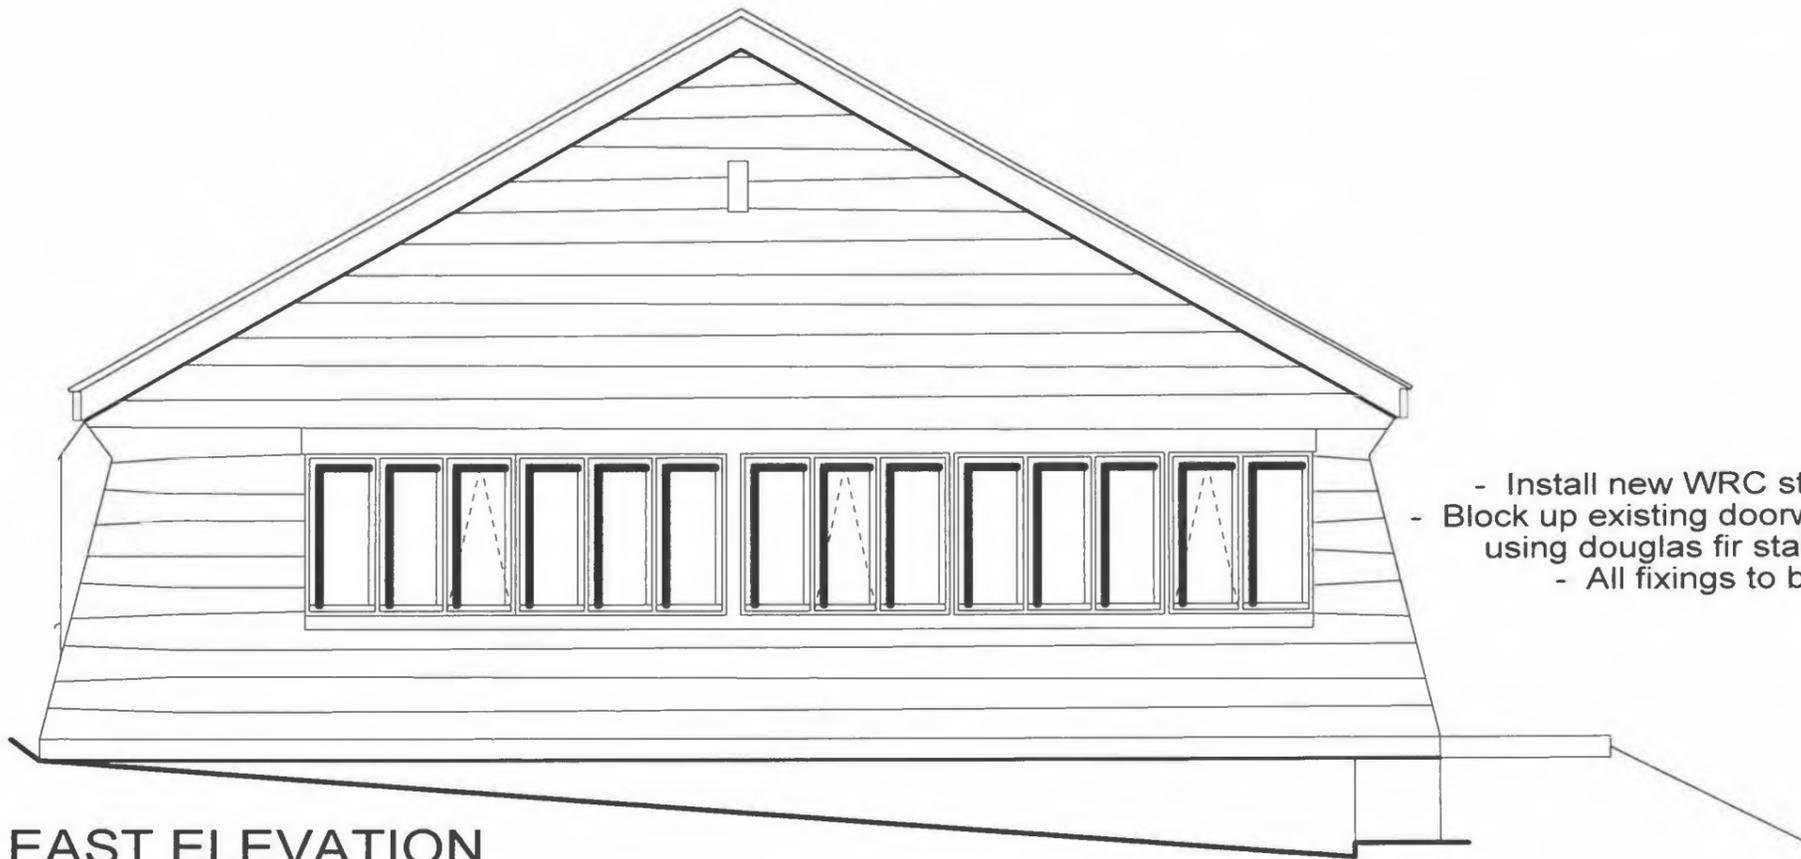

EAST ELEVATION

- Install new WRC stepped glazed DG Units
- Block up existing doorway to SE corner and make good using douglas fir stained boards to match existing.
- All fixings to be in Stainless steel

Client:
West England Forest District

Project:
Cockercombe office Refurbishment


Grid ref: XXXX

Title:
Proposed South and East Elevations

Date: Sept 17
Drawn: B.W. Kedward

Scale: 1:50 @ A3
Dimensions in millimetres

Drawing No.
17/Quant01/008

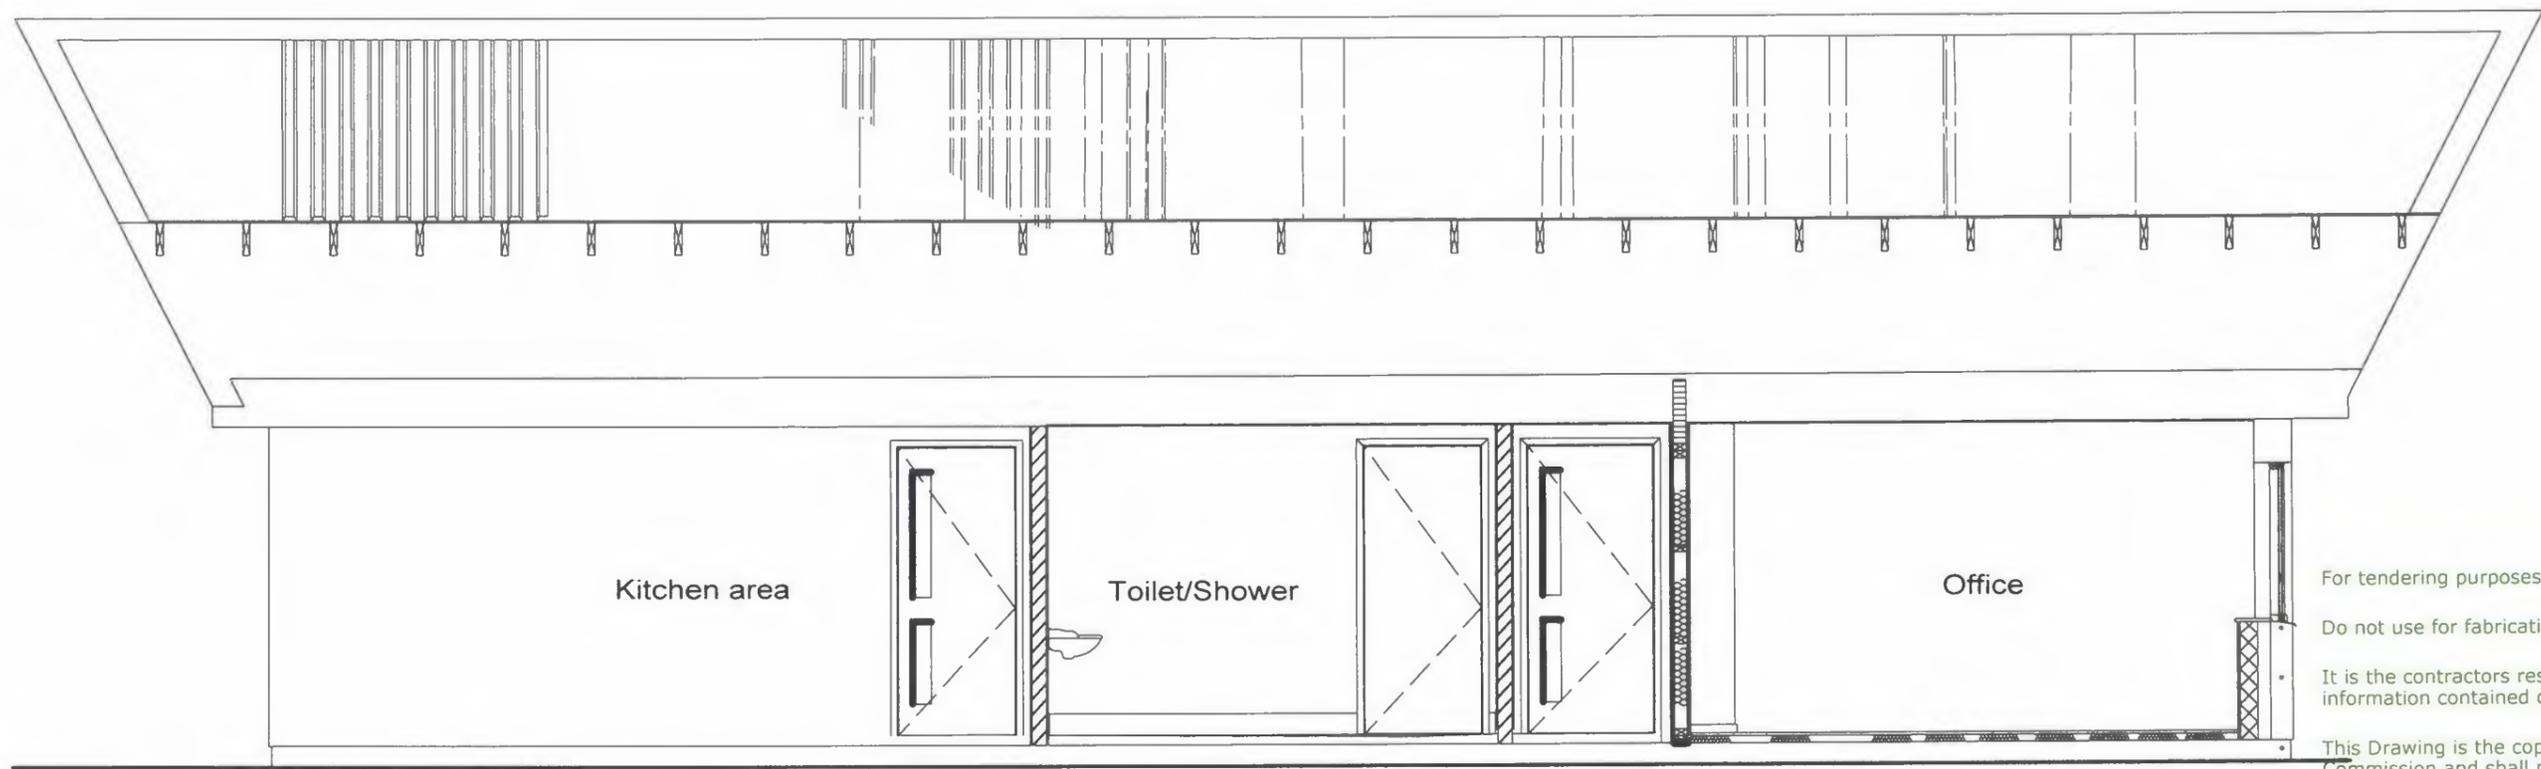

Kitchen area

Toilet/Shower

Office


For tendering purposes only.

Do not use for fabrication.

It is the contractors responsibility to check all information contained on this drawing.

This Drawing is the copyright of the Forestry Commission and shall not be used for any purpose, or copied, or communicated to any other party without the written consent of the Forestry Commission.

SECTION AA

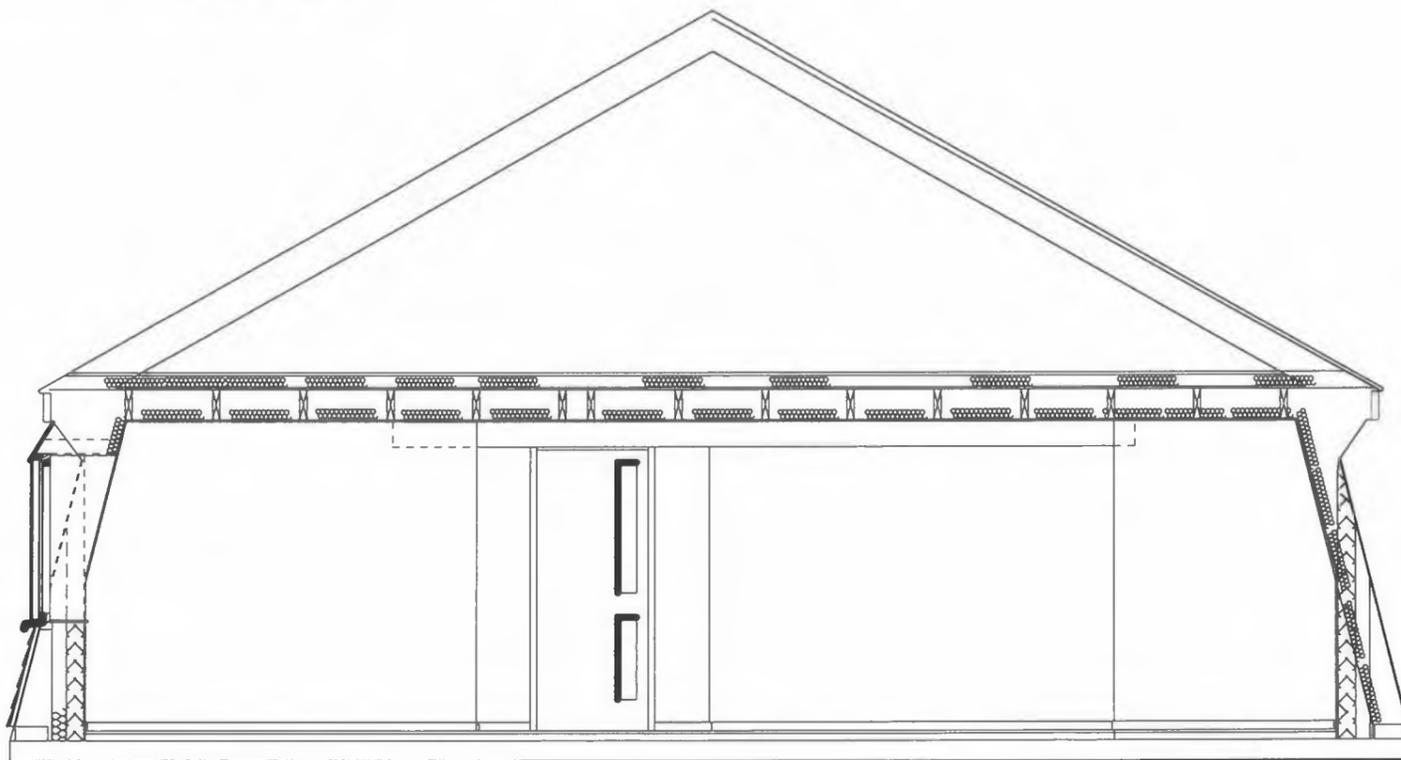

SECTION BB

Client:

West England Forest District

Project:

Cockercombe office Refurbishment

Grid ref: XXXX

Title:

Section AA & BB

Date:

Nov 17

Drawn:

B.W. Kedward

Scale:

1:50 @ A3


Dimensions in millimetres

Drawing No.

17/Quant01/09



Forestry Commission
 England
 Bank House
 Bank Street, Coleford
 Gloucestershire
 GL16 8BA

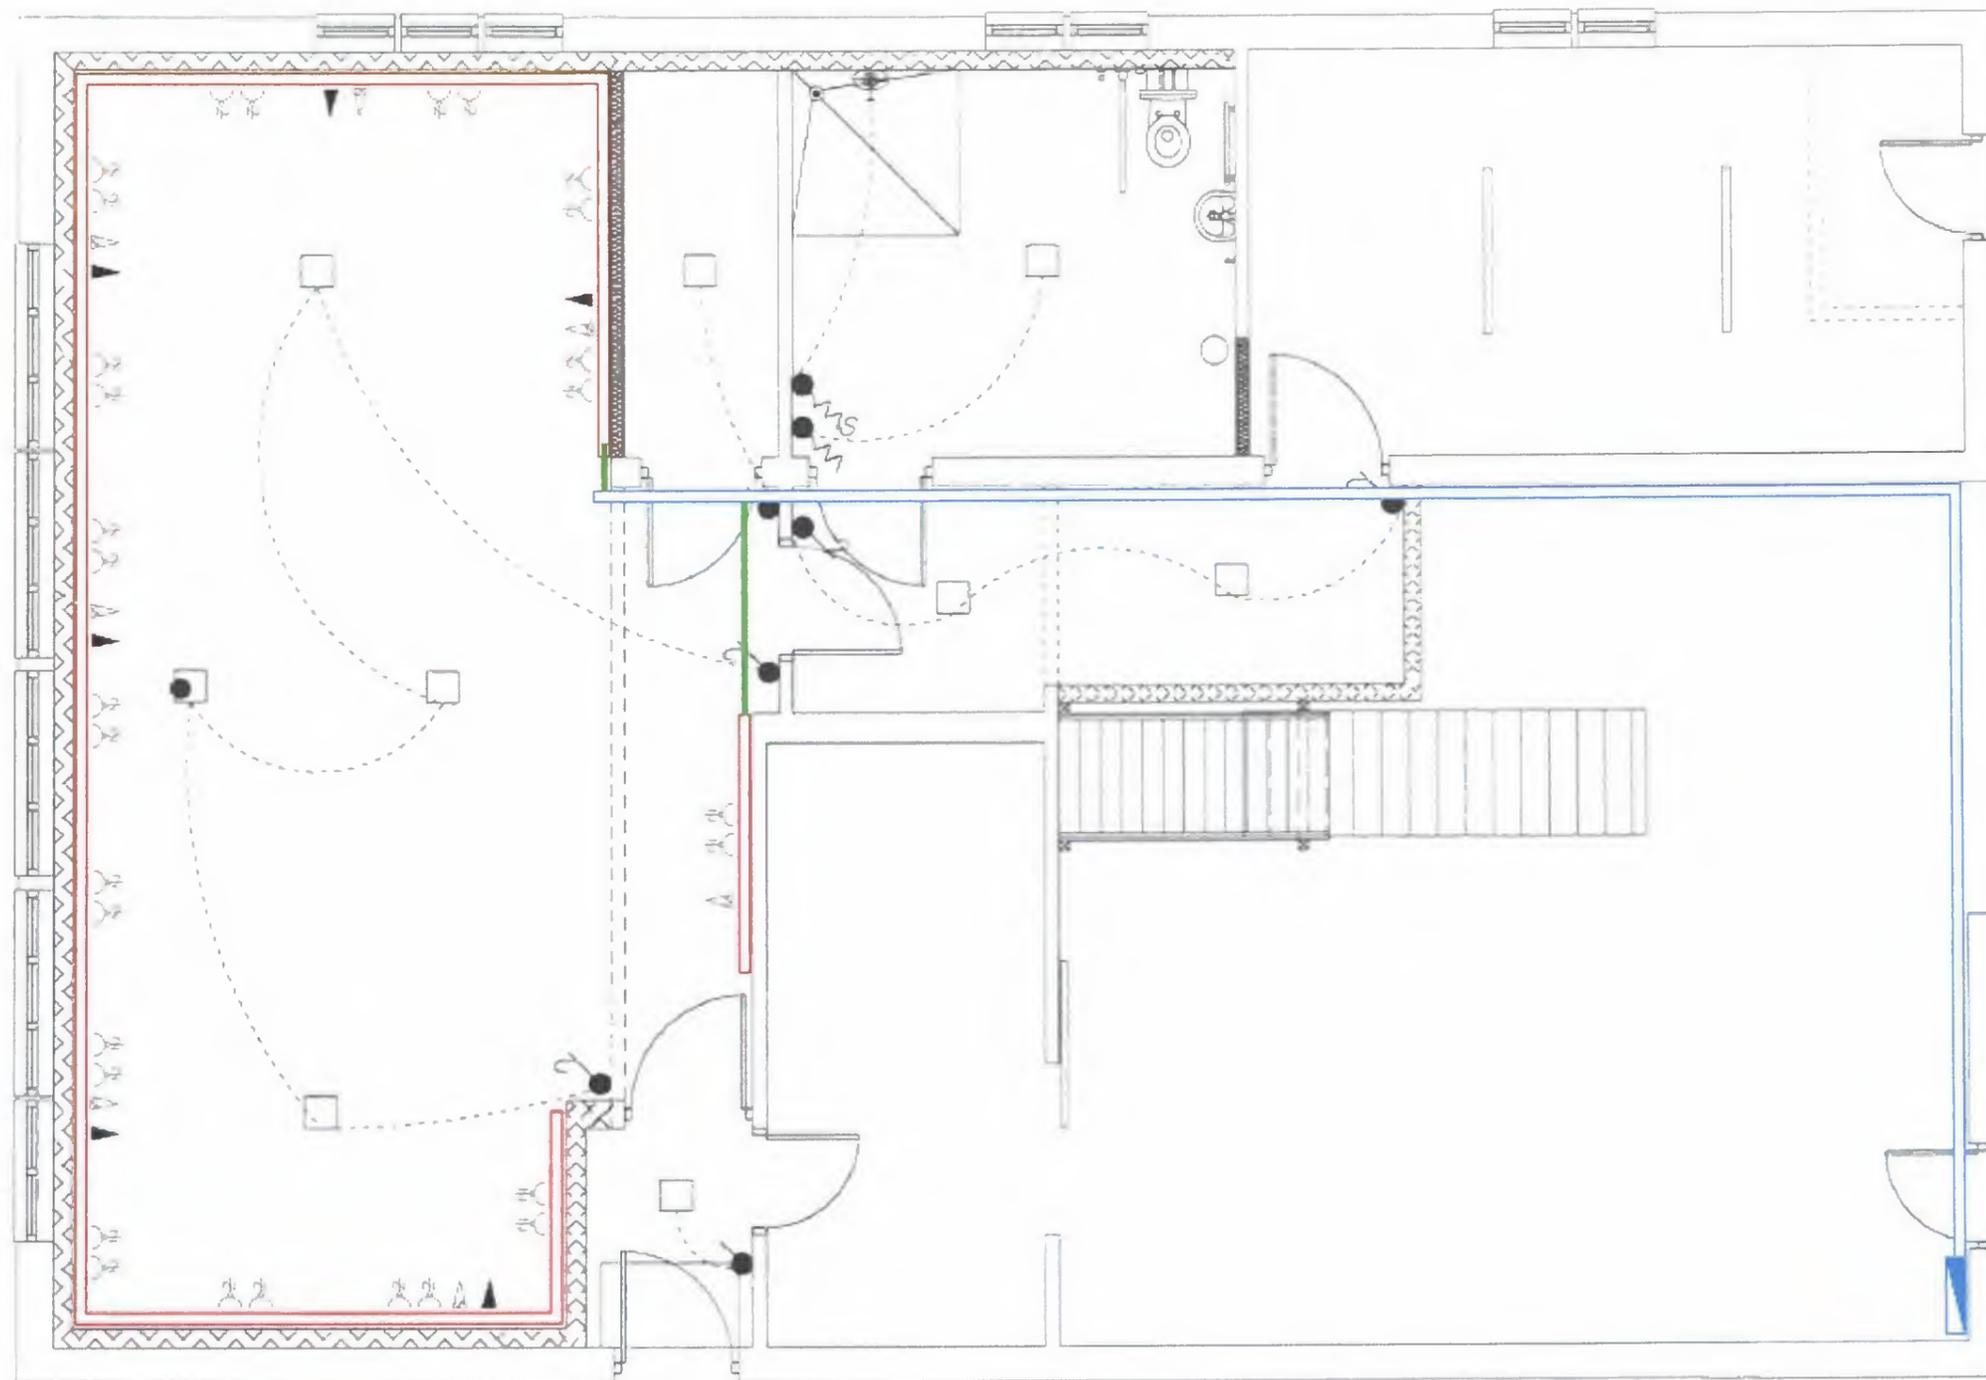

-  Data point
-  Telephone point
-  2 gang socket outlet
-  2 compartment dado trunking, mounted above desk height
-  Existing trunking extended through
-  Consumer unit
-  Conduit feed to dado trunking

- For tendering purposes only.
- Do not use for fabrication.
- It is the contractor's responsibility to check all information contained on this drawing.
- This Drawing is the copyright of the Forestry Commission and shall not be used for any purpose, or copied, or communicated to any other party without the written consent of the Forestry Commission.

Client:
West England Forest District

Project:
Cockercombe Office

Grid ref: XXXX

Title:
Proposed Electrical Floor plan

Date: **October 17** Drawn: **B.W. Kedward**

Scale:
 1:50 @ A3
 Dimensions in millimetres

Drawing No.
17/Quant01/010


Forestry Commission
 England
 Bank House
 Bank Street, Coleford
 Gloucestershire
 GL16 8BA