

GENERAL NOTES:

1. This drawing is not an Architects drawing and must not be interpreted as such.
2. Do not scale off this drawing.
3. This drawing must not be used for construction or installation purposed unless stated.
4. All dimensions must be verified on site before completing shop drawings or setting out the work.
5. This drawing to be read in conjunction with the relevant technical specifications.
6. This drawing is to be read in conjunction with Architectural and Structural Engineers drawings.

- | | |
|----------------------------|-------------------------------|
| HW - Hot Water | NRV - Non Return Valve |
| HL - High Level | S/C - Stop Cock |
| LL - Low Level | C/V - Control Valve |
| TA - To Above | DRV - Double Regulating Valve |
| TB - To Below | LSV - Lock Shield Valve |
| FA - From Above | IV - Isolation Valve |
| FB - From Below | STR - Strainer |
| SS - Stub Stack | HTG - Heating |
| AAV - Air Admittance Valve | CW - Cold Water |
| SVP - Soil Vent Pipe | TD - Tundish |
| DCV - Double Check Valve | F - Flow |
| SV - Solenoid Valve | R - Return |
| NRV - Non Return Valve | |

- | | |
|-------------------|-------|
| Pipes Hidden H/L | ----- |
| Pipes Hidden L/L | ----- |
| Pipes Exposed H/L | ----- |
| Pipes Solid L/L | ----- |

Fire Protection Notes:


- **Ductwork:** Where ductwork crossed a protected escape route or passes through a fire rated floor. Ducts shall be provided with fire dampers or for PVC flat duct, approved fire wrap.
- **Soil Pipework:** Where passing through fire rated floors shall be fitting with approved fire collars.
- **Small Services:** ie. Small bore pipework and cabling. All penetrations passing through fire rated structure shall be suitably fire stopped in accordance with approved details.

Electrical Legend:

- Ceiling Speaker
- Cupboard Door Micro-Switch to control Cupboard Lighting
- Varielight Lighting Switch
- Varielight Dimmable Lighting Switch
- Ceiling Movement Sensor
- Motorised Blind connection

Lighting Legend:

- Wall mounted Illuma Lumapar LED Spotlights
- Astro Messina Frosted.
- Astro External Wall Light. IP65
- Fluorescent Light
- 5a Socket
- Display Light
- Orlight mini stainless steel LED. IP65
- Orlight Marine grade mini projector. IP65
- Illuma Lumapar LED spotlight - track mounted.
- Existing chandelier to be tested and retained. New 12W LED bulbs to be installed.
- Illuma Lumapar LED spotlight - Wall Mounted
- Grok Candle Chandelier

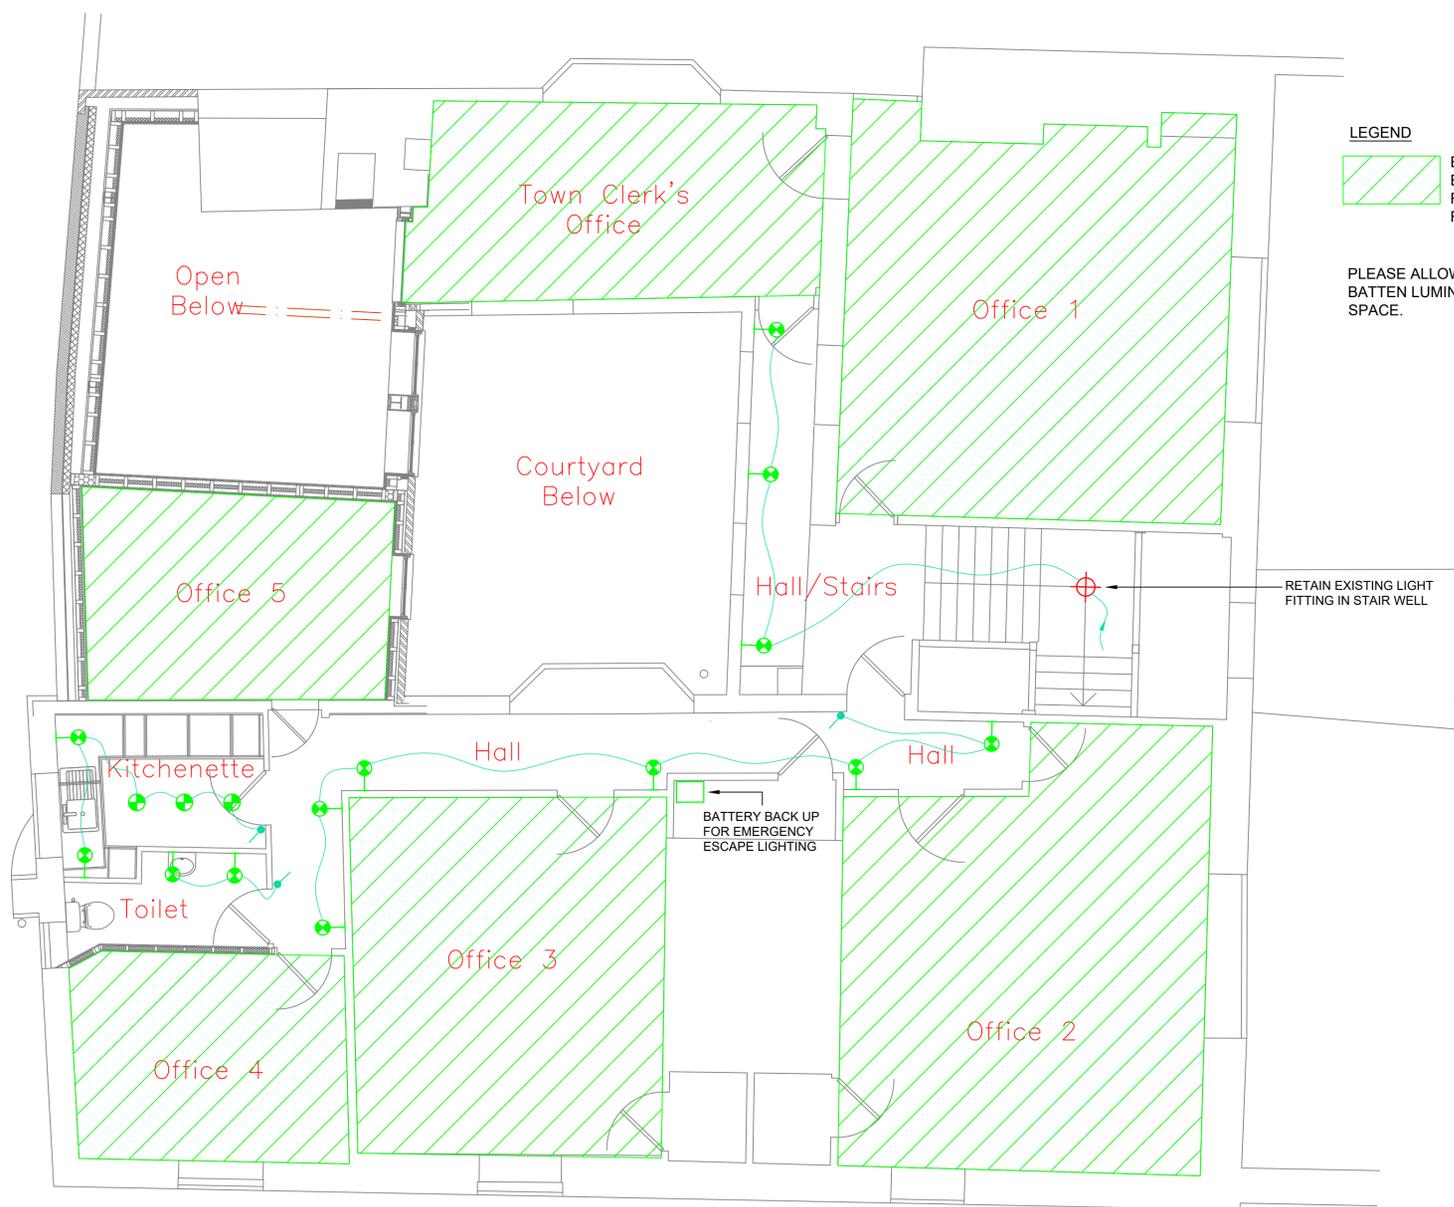

LEGEND

EXISTING LIGHTING TO REMAIN. ALL EXISTING LIGHTING TO BE REWIRED & REFITTED. NEW SWITCHES REQUIRED.

PLEASE ALLOW FOR 8 No. LED BATTEN LUMINAIRES IN THE LOFT SPACE.

RETAIN EXISTING LIGHT FITTING IN STAIR WELL

BATTERY BACK UP FOR EMERGENCY ESCAPE LIGHTING

REV	MODIFICATIONS	DATE
T0	TENDER ISSUE	15/01/2020
P4	STAIR LIGHT REVISED. LEGEND UPDATED.	14/01/2020
P3	LEGEND UPDATED.	13/01/2020
P2	UPDATED TO ARCHITECT'S COMMENTS.	17/12/2019
P1	REVISED TO SHOW EXISTING LIGHTING TO REMAIN.	09/12/2019
P0	INFORMATION	02/12/2019

CARNELL WARREN

ASSOCIATES
DUKE HOUSE, DUKE STREET, WOKING, GU215BA
PROJECTS@CARNELLWARREN.CO.UK 01483 730995

PROJECT
The Almonry Battle

TITLE
First Floor Lighting Layout

CLIENT
Battle Town Council

SCALE @ A1: **1:50** DATE: **Nov '19** DRN: **SLC**

DRAWING NO.: **1509/E/203** REV: **T0**